

MCDERMOTT		Woodfibre LNG EPFC Project Project No. 350106	
Engineering Review Status Code 1 - No Comments		By: oscar.grisales2	Date: May 22, 2025
These comments do not relieve the supplier of his responsibility to meet the requirements of the PO.			



SUPPLIER DOCUMENT COVER SHEET



350106 Woodfibre LNG Project

Supplier Name:	LBLNG
Purchase Order Title:	Site Construction
Equipment / Tag Number(s):	N/A
Supplier Document Number	350106-SC-CV-001-SD-110300
SDR Code	F81

Supplier's Revision Record

A	APR142025	Issued for Permit	D.Eshpeter	P.Streith	A.Rimbey
Rev	Date	Issue State	By	Checked	Approved

Project Document Number

Project Number	Purchase Order Number				Seq. No.	Purchaser's Rev.
350106	SC-CV-001	-	SD	-	110300	1

Document Title: 01-BLG-0011 Instrument Air Compressor Building - Architectural Permit Drawing Package

SUPPLIER DOCUMENT REVIEW STATUS

Purchaser's review of Supplier's documents does not relieve Supplier of the responsibility for correctness under the Purchase Order. Permission to proceed does not constitute acceptance of design, detail and calculations, test methods or materials developed or selected by the Supplier and does not relieve the Supplier from full compliance with the Purchase Order or any other obligations, nor detract from any of the Purchaser's rights.

Purchaser's Review Stamp

Should the Supplier consider that any comments made by the Purchaser change the Scope of Supply, the Supplier shall advise the price and delivery implications of such changes within five working days of receipt. The Supplier must not incorporate such changes without prior approval of the Purchaser of the revised price and/or delivery period. RETROSPECTIVE CLAIMS WILL NOT BE CONSIDERED.

This document consists of this front sheet plus 6 number of pages.

Construction - Symbol Legend

- FD INDICATES FLOOR DRAINS. REFER TO MECHANICAL DRAWINGS
- RWL INDICATES RAIN WATER LEADER DOWN TO PRECAST CONCRETE SPLASH PAD

Construction - Keynote Legend

- C1 PRE-MANUFACTURED ICE SHIELD GABLE CANOPY ABOVE SUMP PIT. REFER TO STRUCTURAL DRAWINGS
- C2 SUMP PIT. REFER TO STRUCTURAL DRAWINGS
- C3 OUTLINE OF TRUCK ACCESS
- C4 STRUCTURAL BRACING. REFER TO STRUCTURAL DRAWINGS
- C5 MECHANICAL EQUIPMENT. REFER TO MECHANICAL DRAWINGS
- C6 FIRE DEPARTMENT CONNECTION. REFER TO MECHANICAL DRAWINGS
- C7 GALVANIZED STEEL ELEVATED CATWALK WITH GALVANIZED METAL GRATING DECKING COMPLETE WITH FIXED CAGED LADDERS AND GALVANIZED METAL RAILING AT 1070mm HIGH. REFER TO STRUCTURAL DRAWINGS
- C8 CONCRETE HOUSEKEEPING PAD/PIPE SUPPORT PAD. REFER TO STRUCTURAL DRAWINGS
- C9 PRE-ENGINEERED STRUCTURAL STEEL COLUMN. REFER TO PRE-ENGINEERED DRAWINGS

- C10 GALVANIZED STEEL PLATFORM WITH GRATING DECKING FOR MECHANICAL EQUIPMENT. REFER TO STRUCTURAL DRAWINGS
- C11 INDICATES FIRE ALARM ANNUNCIATOR PANEL. REFER TO ELECTRICAL DRAWINGS
- C12 INDICATES BRACKET MOUNTED FIRE EXTINGUISHER. REFER TO MECHANICAL DRAWINGS
- C13 HOSE BIBB. REFER TO MECHANICAL DRAWINGS

Dimension - General Notes

1. EXTERIOR DIMENSION INDICATE FACE OF STEEL GIRT UNLESS NOTED OTHERWISE.
2. ALL GRIDLINES ARE TO CENTERLINE OF STRUCTURE UNLESS NOTED OTHERWISE

GENERAL NOTES:

1. ALL DIMENSIONS ARE IN MILLIMETER, UNO.
2. ALL DRAWING REFERENCE CALLOUTS ARE PREFIXED WITH 350106-SC-CV-001-SD, TYPICAL.

SHEET REFERENCES:



350106-SC-CV-001-SD-110001 - COVER SHEET
350106-SC-CV-001-SD-110004 - CONSTRUCTION ASSEMBLIES

HOLDS:

		SUPPLIER/SUBCONTRACTOR DRAWING DECAL WOODFIBRE LNG			
Supplier Name: LBLNG					
SDR Code(s): F81,H81					
Equipment/Tag Number(s):					
Project Number	Purchase Order Number		Seq No	Purchaser's Revision	
350106	SC-CV-001	SD	110006	2	

This document or drawing is the sole property and copyright of CB&I LLC and contains confidential and proprietary information. This document or drawing cannot be reproduced, copied, retained or used, in whole or in part, without written consent of CB&I LLC, a McDermott company.

Form Number: CHS-670-65-FM-50006 Issued for Use: 21DEC2017

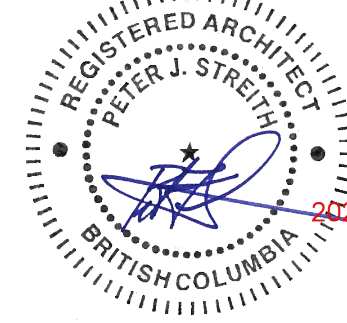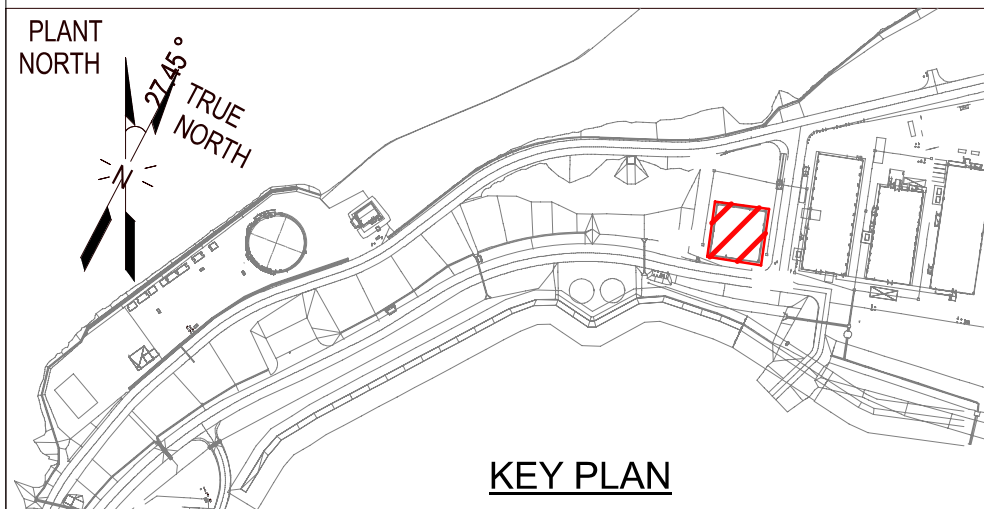

S2ARCHITECTURE
CALGARY | EDMONTON | VANCOUVER

B	ISSUED FOR BUILDING PERMIT	DE	PS	GW	2025FEB13
A	ISSUED FOR 30% FORMAL REVIEW	DE	PS	GW	2024NOV08
NO.	REVISION	DRWN	CK'D	APPD	DATE

MCDERMOTT

THIS DOCUMENT OR DRAWING IS THE SOLE PROPERTY AND COPYRIGHT OF CB&I LLC, A MCDERMOTT COMPANY, AND CONTAINS CONFIDENTIAL AND PROPRIETARY INFORMATION. THIS DOCUMENT OR DRAWING CANNOT BE REPRODUCED, COPIED, RETAINED OR USED, IN WHOLE OR IN PART, WITHOUT WRITTEN CONSENT OF CB&I LLC.

Drawn By	Drawn Date	Chkd By	Chkd Date	Aprvd By	Aprvd Date	Scale
DE	2025FEB13	PS	2025FEB13	GW	2025FEB13	AS NOTED



Woodfibre LNG Project


CLIENT DWG NO:

INDUSTRIAL AREA
01-BLG-0011-INSTRUMENT AIR COMPRESSOR BUILDING
MAIN FLOOR CONSTRUCTION PLAN
ARCHITECTURAL

FOR:

Woodfibre LNG Limited

PROJ. NO:	DWG NO:	REV:
350106	350106-SC-CV-001-SD-110006	

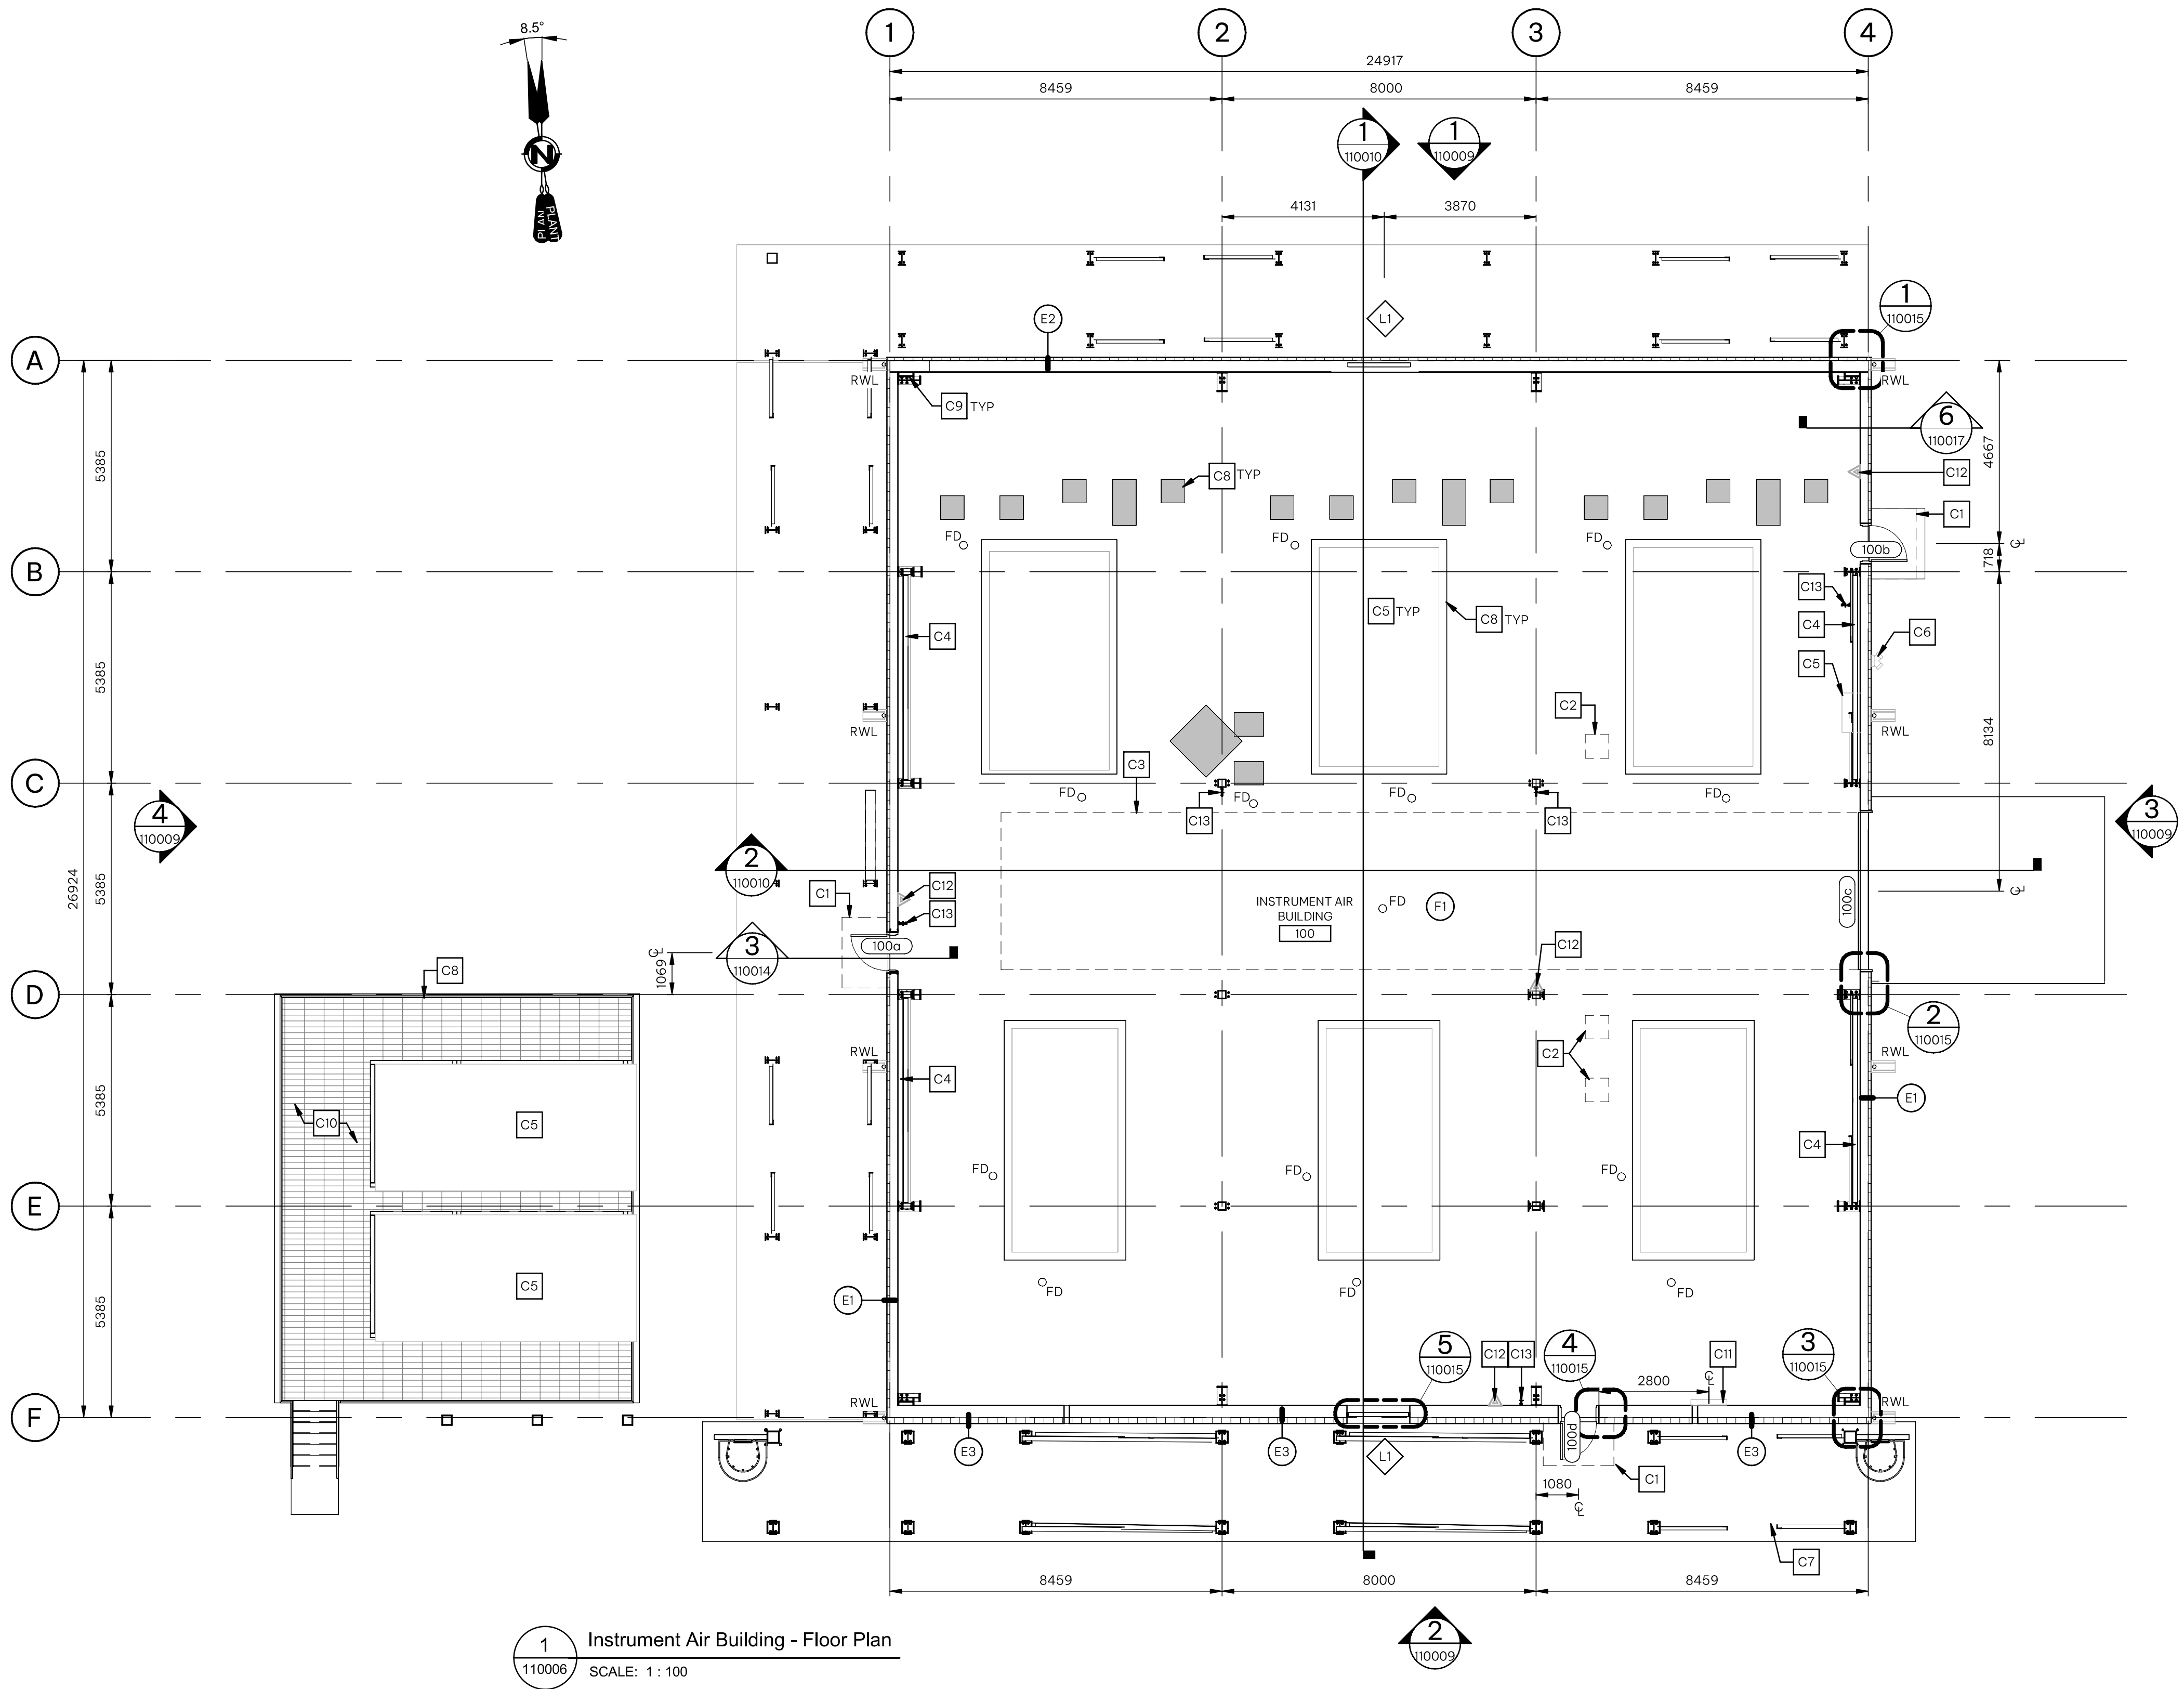

Roof Plan - Code Legend

- R1 PREFINISHED RAIN GUTTER C/W RAINWATER LEADER
- R2 CONTINUOUS SNOW RETENTION SYSTEM
- R3 GALVANIZED STEEL CATWALK. REFER TO STRUCTURAL DRAWINGS
- R4 OUTLINE OF CANOPY BELOW CATWALK
- R5 GALVANIZED STEEL PLATFORM WITH GRATING DECKING. REFER TO STRUCTURAL DRAWINGS

Roof Plan - Symbol Legend

- INDICATES DIRECTION OF ROOF SLOPE TO DRAIN
- RWL INDICATES RAIN WATER LEADER DOWN TO PRECAST CONCRETE SPLASH PAD

Roof Plan - General Notes

1. ALL ROOFING CONSTRUCTION AND PROCEDURES TO BE EXECUTED AND CARRIED OUT AS PER THE 'ROOFING CONTRACTORS ASSOCIATION OF BRITISH COLUMBIA' MANUAL AND ITS RECOMMENDATIONS U.N.O.

GENERAL NOTES:

1. ALL DIMENSIONS ARE IN MILLIMETER, UNO.
2. ALL DRAWING REFERENCE CALLOUTS ARE PREFIXED WITH 350106-SC-CV-001-SD, TYPICAL.



SHEET REFERENCES:

350106-SC-CV-001-SD-110001 - COVER SHEET

350106-SC-CV-001-SD-110004 - CONSTRUCTION ASSEMBLIES

HOLDS:

		SUPPLIER/SUBCONTRACTOR DRAWING DECAL WOODFIBRE LNG			
Supplier Name: LBLNG					
SDR Code(s): F81,H81					
Equipment/Tag Number(s):					
Project Number	Purchase Order Number		Seq No	Purchaser's Revision	
350106	SC-CV-001	SD	110007	2	
This document or drawing is the sole property and copyright of CB&I LLC and contains confidential and proprietary information. This document or drawing cannot be reproduced, copied, retained or used, in whole or in part, without written consent of CB&I LLC, a McDermott company.					
Form Number: CHS-670-62-FM-30006					
Issued for Use: 21DEC2017					

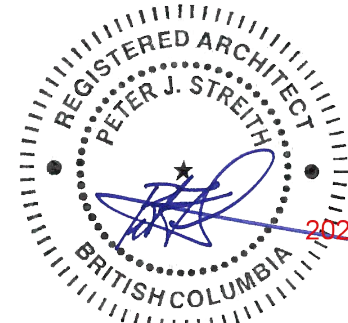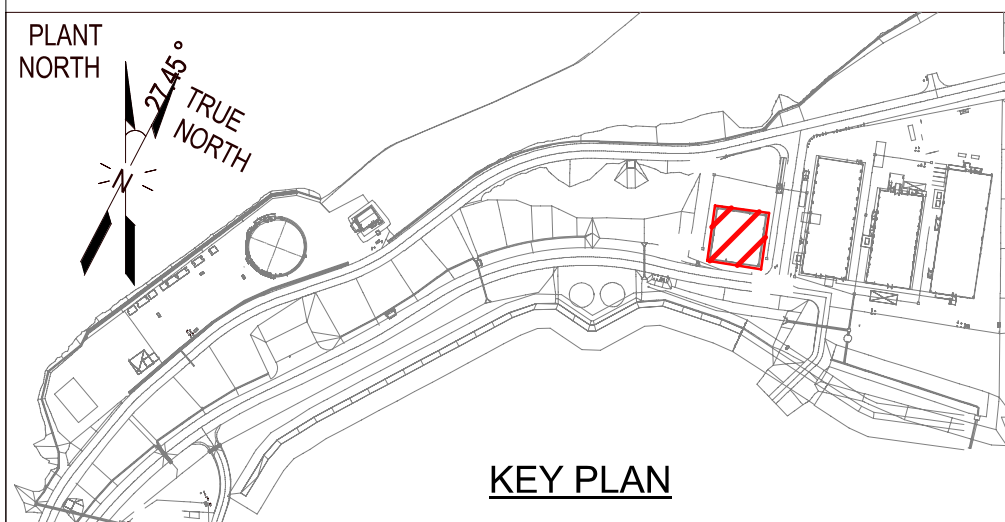

S2ARCHITECTURE
CALGARY | EDMONTON | VANCOUVER

B	ISSUED FOR BUILDING PERMIT	DE	PS	GW	2025FEB13
A	ISSUED FOR 30% FORMAL REVIEW	DE	PS	GW	2024NOV08
NO.	REVISION	DRWN	CK'D	APPD	DATE

MCDERMOTT

THIS DOCUMENT OR DRAWING IS THE SOLE PROPERTY AND COPYRIGHT OF CB&I LLC, A MCDERMOTT COMPANY, AND CONTAINS CONFIDENTIAL AND PROPRIETARY INFORMATION. THIS DOCUMENT OR DRAWING CANNOT BE REPRODUCED, COPIED, RETAINED OR USED, IN WHOLE OR IN PART, WITHOUT WRITTEN CONSENT OF CB&I LLC.

Drawn By	Drwn Date	Chkd By	Chkd Date	Aprvd By	Aprvd Date	Scale
DE	2025FEB13	PS	2025FEB13	GW	2025FEB13	AS NOTED



Woodfibre LNG Project

CLIENT DWG NO:

INDUSTRIAL AREA

01-BLG-0011-INSTRUMENT AIR COMPRESSOR BUILDING


ROOF PLAN

ARCHITECTURAL

FOR:

Woodfibre LNG Limited

PROJ. NO:	DWG NO:	REV:
350106	350106-SC-CV-001-SD-110007	

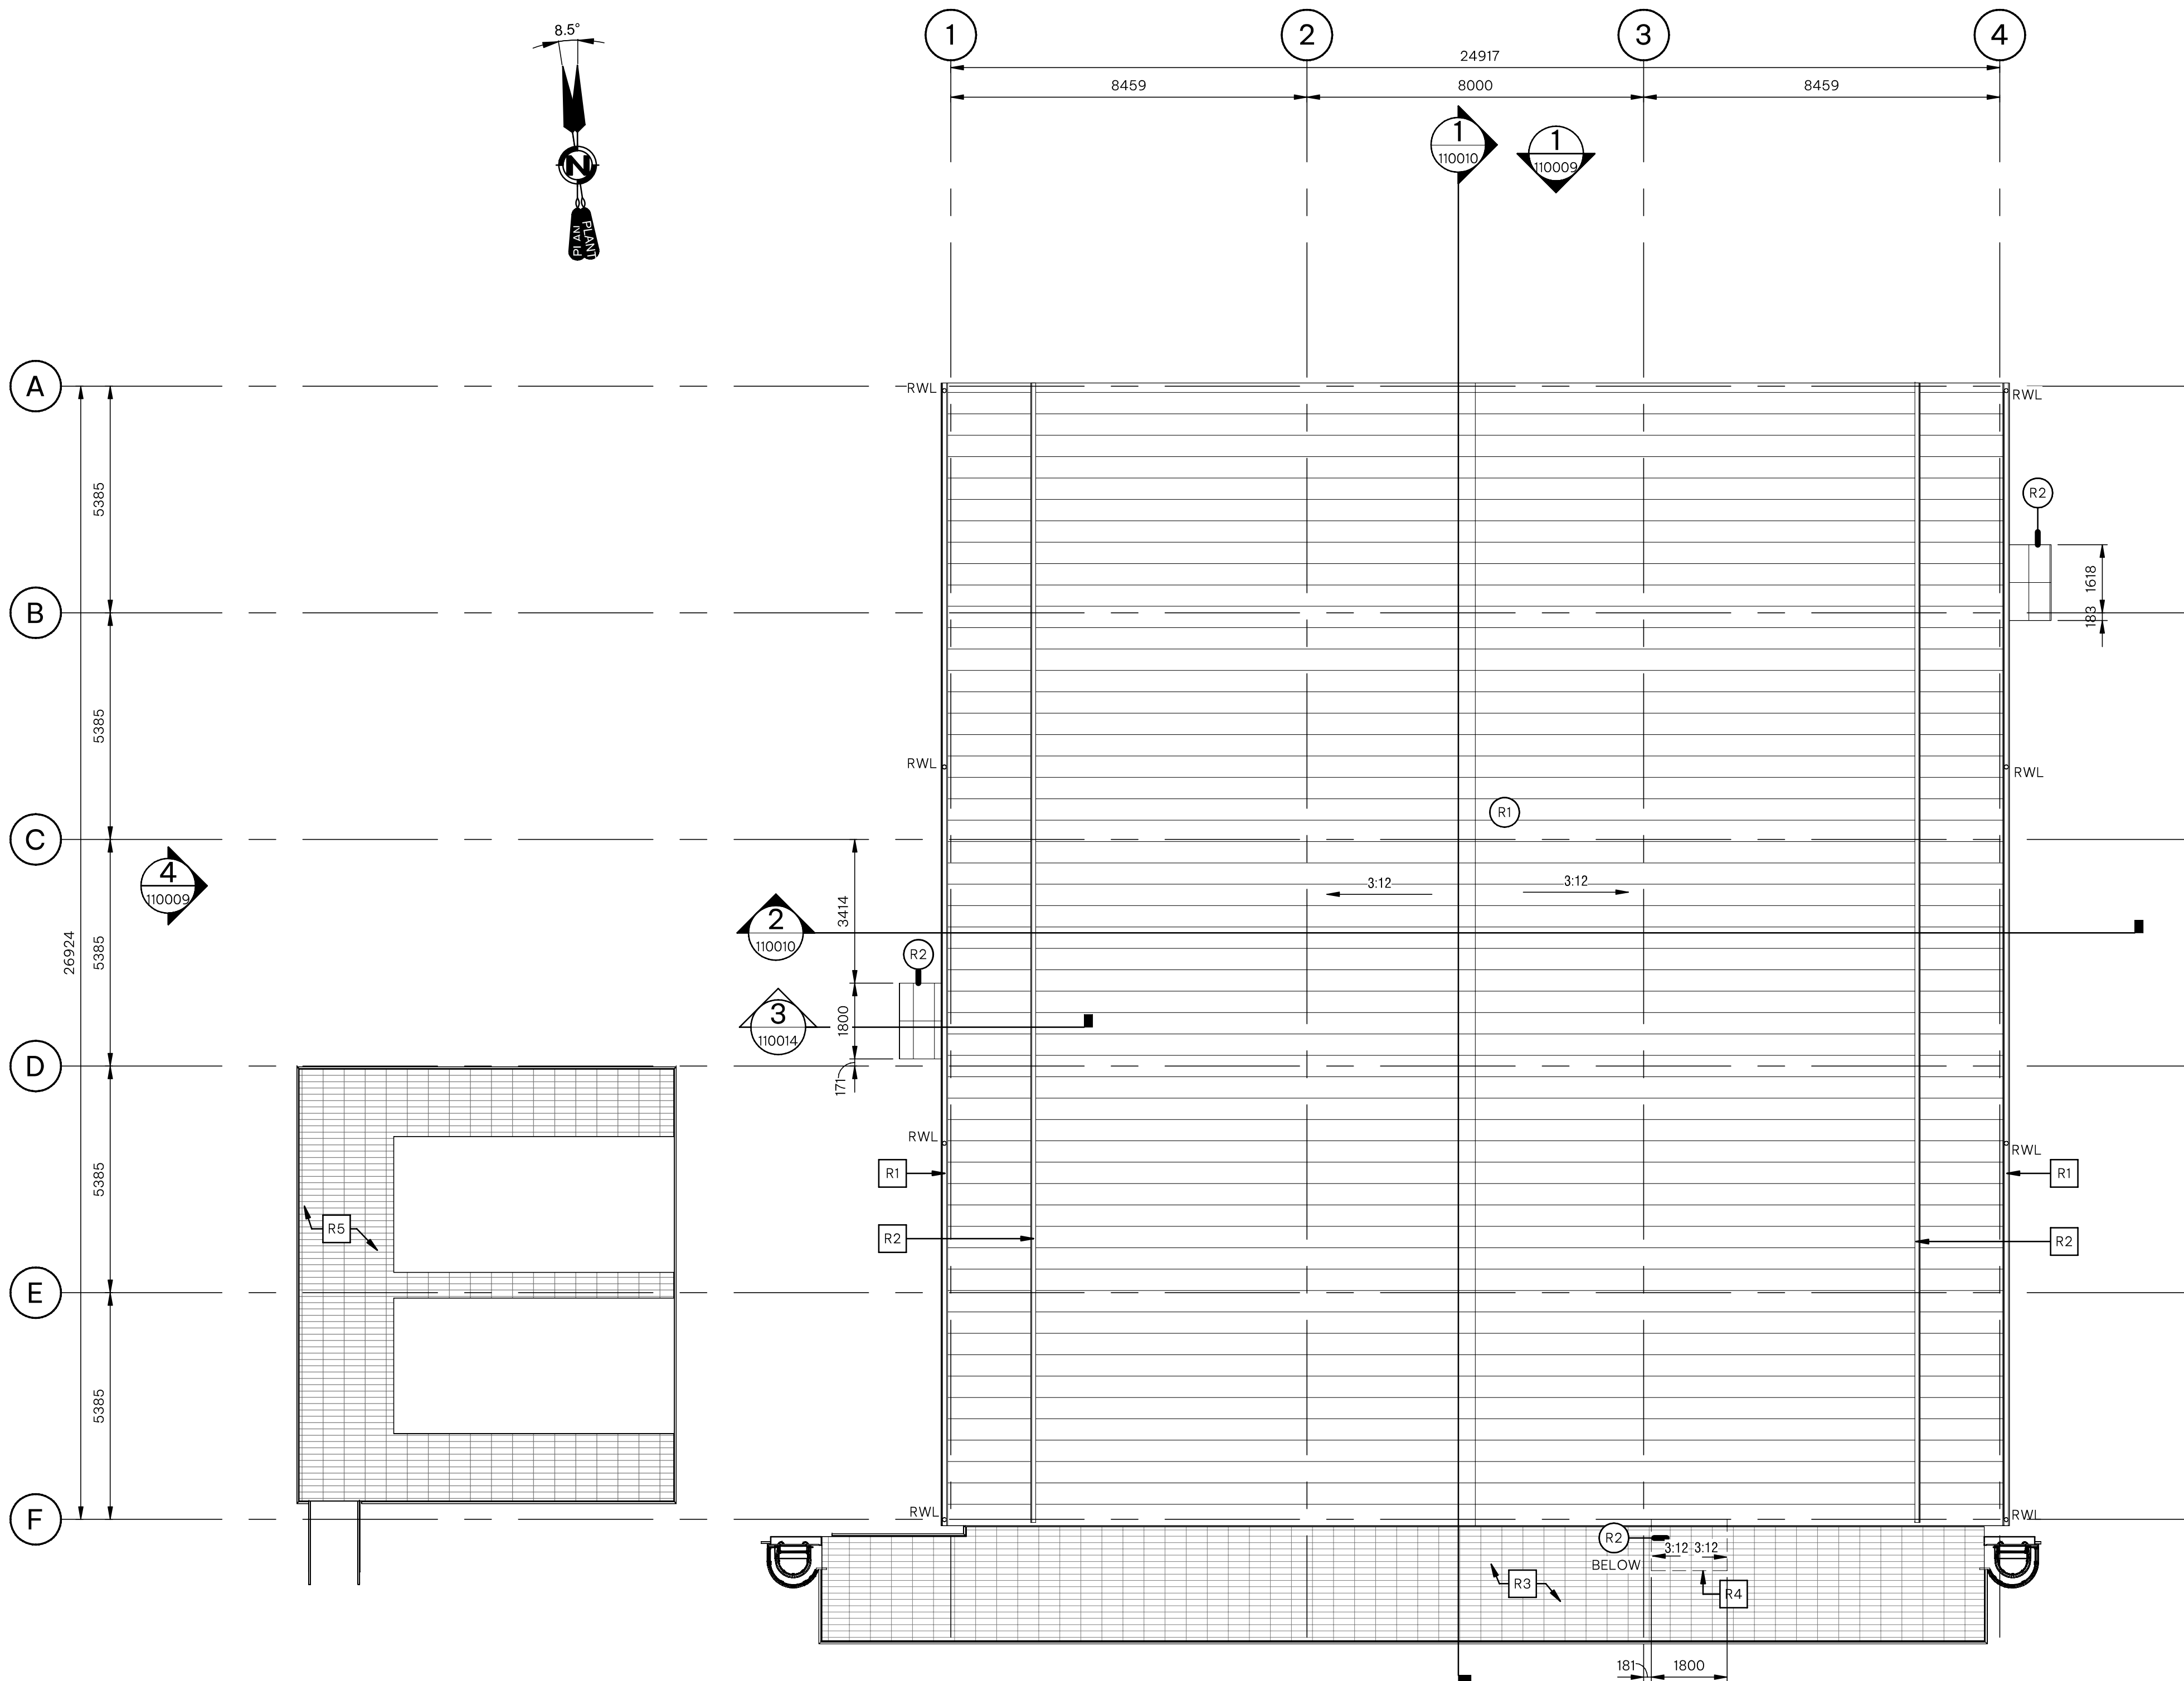

1 Instrument Air Building - Roof Plan
110007 SCALE: 1 : 100

2
1/10009

Exterior Elevation - Code Legend

E1	INSULATED METAL WALL PANEL COLOUR - RAL 160 60 05	E6	PREFINISHED RAIN GUTTER C/W RAINWATER LEADERS	E11	CABLE TRAY/PIPING SUPPORT. NOT IN PACKAGE. SHOWN FOR REFERENCE ONLY	E15	CONCRETE-FACED INSULATION	E19	MECHANICAL EQUIPMENT. REFER TO MECHANICAL DRAWINGS
E2	INSULATED METAL ROOF PANEL COLOUR - RAL 160 60 05	E7	PREFINISHED METAL FASCIA COLOUR TO MATCH ADJACENT CLADDING	E12	GALVANIZED STEEL ELEVATED CATWALK WITH GRATING DECKING AND 100mm HIGH TOE KICK BOTH SIDES. COMPLETE WITH FIXED CAGED LADDERS AND GALVANIZED METAL RAILINGS AT 1070mm HIGH. REFER TO STRUCTURAL DRAWINGS	E16	EXTERIOR WALL PACK LIGHT FIXTURE (TYP). REFER TO ELECTRICAL DRAWINGS	E20	GALVANIZED STEEL PLATFORM WITH GRATING DECKING AND GALVANIZED METAL RAILING AT 1070mm HIGH. REFER TO STRUCTURAL DRAWINGS
E3	EXTERIOR DOOR AND FRAME. REFER TO DOOR SCHEDULE	E8	MECHANICAL EXHAUST HOOD. REFER TO MECHANICAL DRAWINGS	E13	FIRE DEPARTMENT CONNECTION. REFER TO MECHANICAL DRAWINGS	E17	ROTEX CABLE ENTRY POINTS ALONG EXTERIOR WALLS (1050w x 220h). REFER TO ELECTRICAL DRAWINGS	E21	RAIN WATER LEADER DOWN TO PRECAST CONCRETE SPLASH PAD. TYPICAL
E4	PRE-MANUFACTURED ICE SHIELD GABLE CANOPY	E9	LOUVRE. REFER TO SCHEDULE	E14	SINGLE PIPE PENETRATIONS CORE DRILLING THROUGH EXTERIOR WALL. COMPLETE WITH TWO PIECE FLASHING WALL COVER PLATE. TO BE COMPLETED ON SITE BY INSTALLER. REFER TO WINDOW SCHEDULE FOR DIMENSIONS	E18	PROVIDE FRAMED OPENINGS AROUND GROUPED PENETRATIONS THROUGH EXTERIOR WALLS. COMPLETE WITH TWO PIECE FLASHING COVER PLATE. FILL VOID AROUND PIPES WITH CLOSED CELL SPRAY FOAM INSULATION. REFER TO WINDOW SCHEDULE FOR DIMENSIONS	E22	POLE MOUNTED LIGHT FIXTURE (TYP). REFER TO ELECTRICAL DRAWINGS
E5	CONTINUOUS SNOW RETENTION SYSTEM	E10	MECHANICAL DUCT. REFER TO MECHANICAL DRAWINGS						

GENERAL NOTES:


- ALL DIMENSIONS ARE IN MILLIMETER, UNO.
- ALL DRAWING REFERENCE CALLOUTS ARE PREFIXED WITH 350106-SC-CV-001-SD, TYPICAL.

SHEET REFERENCES:

350106-SC-CV-001-SD-110001 - COVER SHEET
350106-SC-CV-001-SD-110006 - MAIN FLOOR - CONSTRUCTION PLAN
350106-SC-CV-001-SD-110007 - ROOF PLAN
350106-SC-CV-001-SD-110011 - MAIN FLOOR - SLAB PLAN

HOLDS:

		SUPPLIER/SUBCONTRACTOR DRAWING DECAL WOODFIBRE LNG			
Supplier Name: LBLNG					
SDR Code(s): F81,H81					
Equipment/Tag Number(s):					
Project Number 350106	Purchase Order Number SC-CV-001	SD	Seq No 110009	Purchaser's Revision 2	
This document or drawing is the sole property and copyright of CB&I LLC and contains confidential and proprietary information. This document or drawing cannot be reproduced, copied, retained or used, in whole or in part, without written consent of CB&I LLC, a McDermott company.					
Form Number: CHS-870-02-FRM-00006 Issued for Use: 21DEC2017					

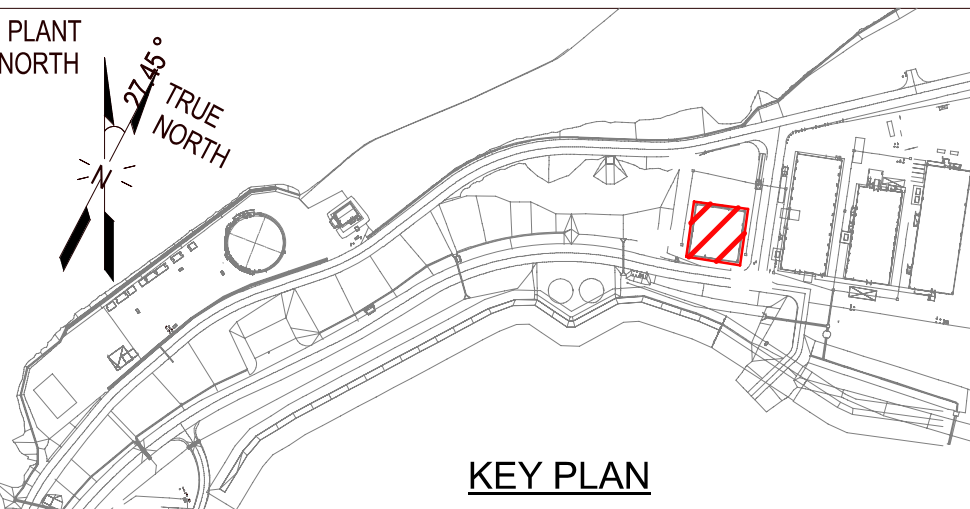


S2ARCHITECTURE
CALGARY | EDMONTON | VANCOUVER

B	ISSUED FOR BUILDING PERMIT	DE	PS	GW	2025FEB13
A	ISSUED FOR 30% FORMAL REVIEW	DE	PS	GW	2024NOV08
NO.	REVISION	DRWN	CK'D	APPD	DATE

MCDERMOTT

THIS DOCUMENT OR DRAWING IS THE SOLE PROPERTY AND COPYRIGHT OF CB&I LLC, A MCDERMOTT COMPANY, AND CONTAINS CONFIDENTIAL AND PROPRIETARY INFORMATION. THIS DOCUMENT OR DRAWING CANNOT BE REPRODUCED, COPIED, RETAINED OR USED, IN WHOLE OR IN PART, WITHOUT WRITTEN CONSENT OF CB&I LLC.

Drawn By	Drwn Date	Chkd By	Chkd Date	Aprvd By	Aprvd Date	Scale
DE	2025FEB13	PS	2025FEB13	GW	2025FEB13	AS NOTED

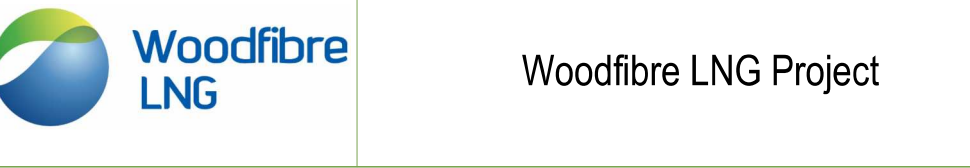


Woodfibre LNG Project


CLIENT DWG NO:

INDUSTRIAL AREA
01-BLG-0011-INSTRUMENT AIR COMPRESSOR BUILDING
BUILDING ELEVATIONS
ARCHITECTURAL


FOR: Woodfibre LNG Limited		
PROJ. NO: 350106	DWG NO: 350106-SC-CV-001-SD-110009	REV: B

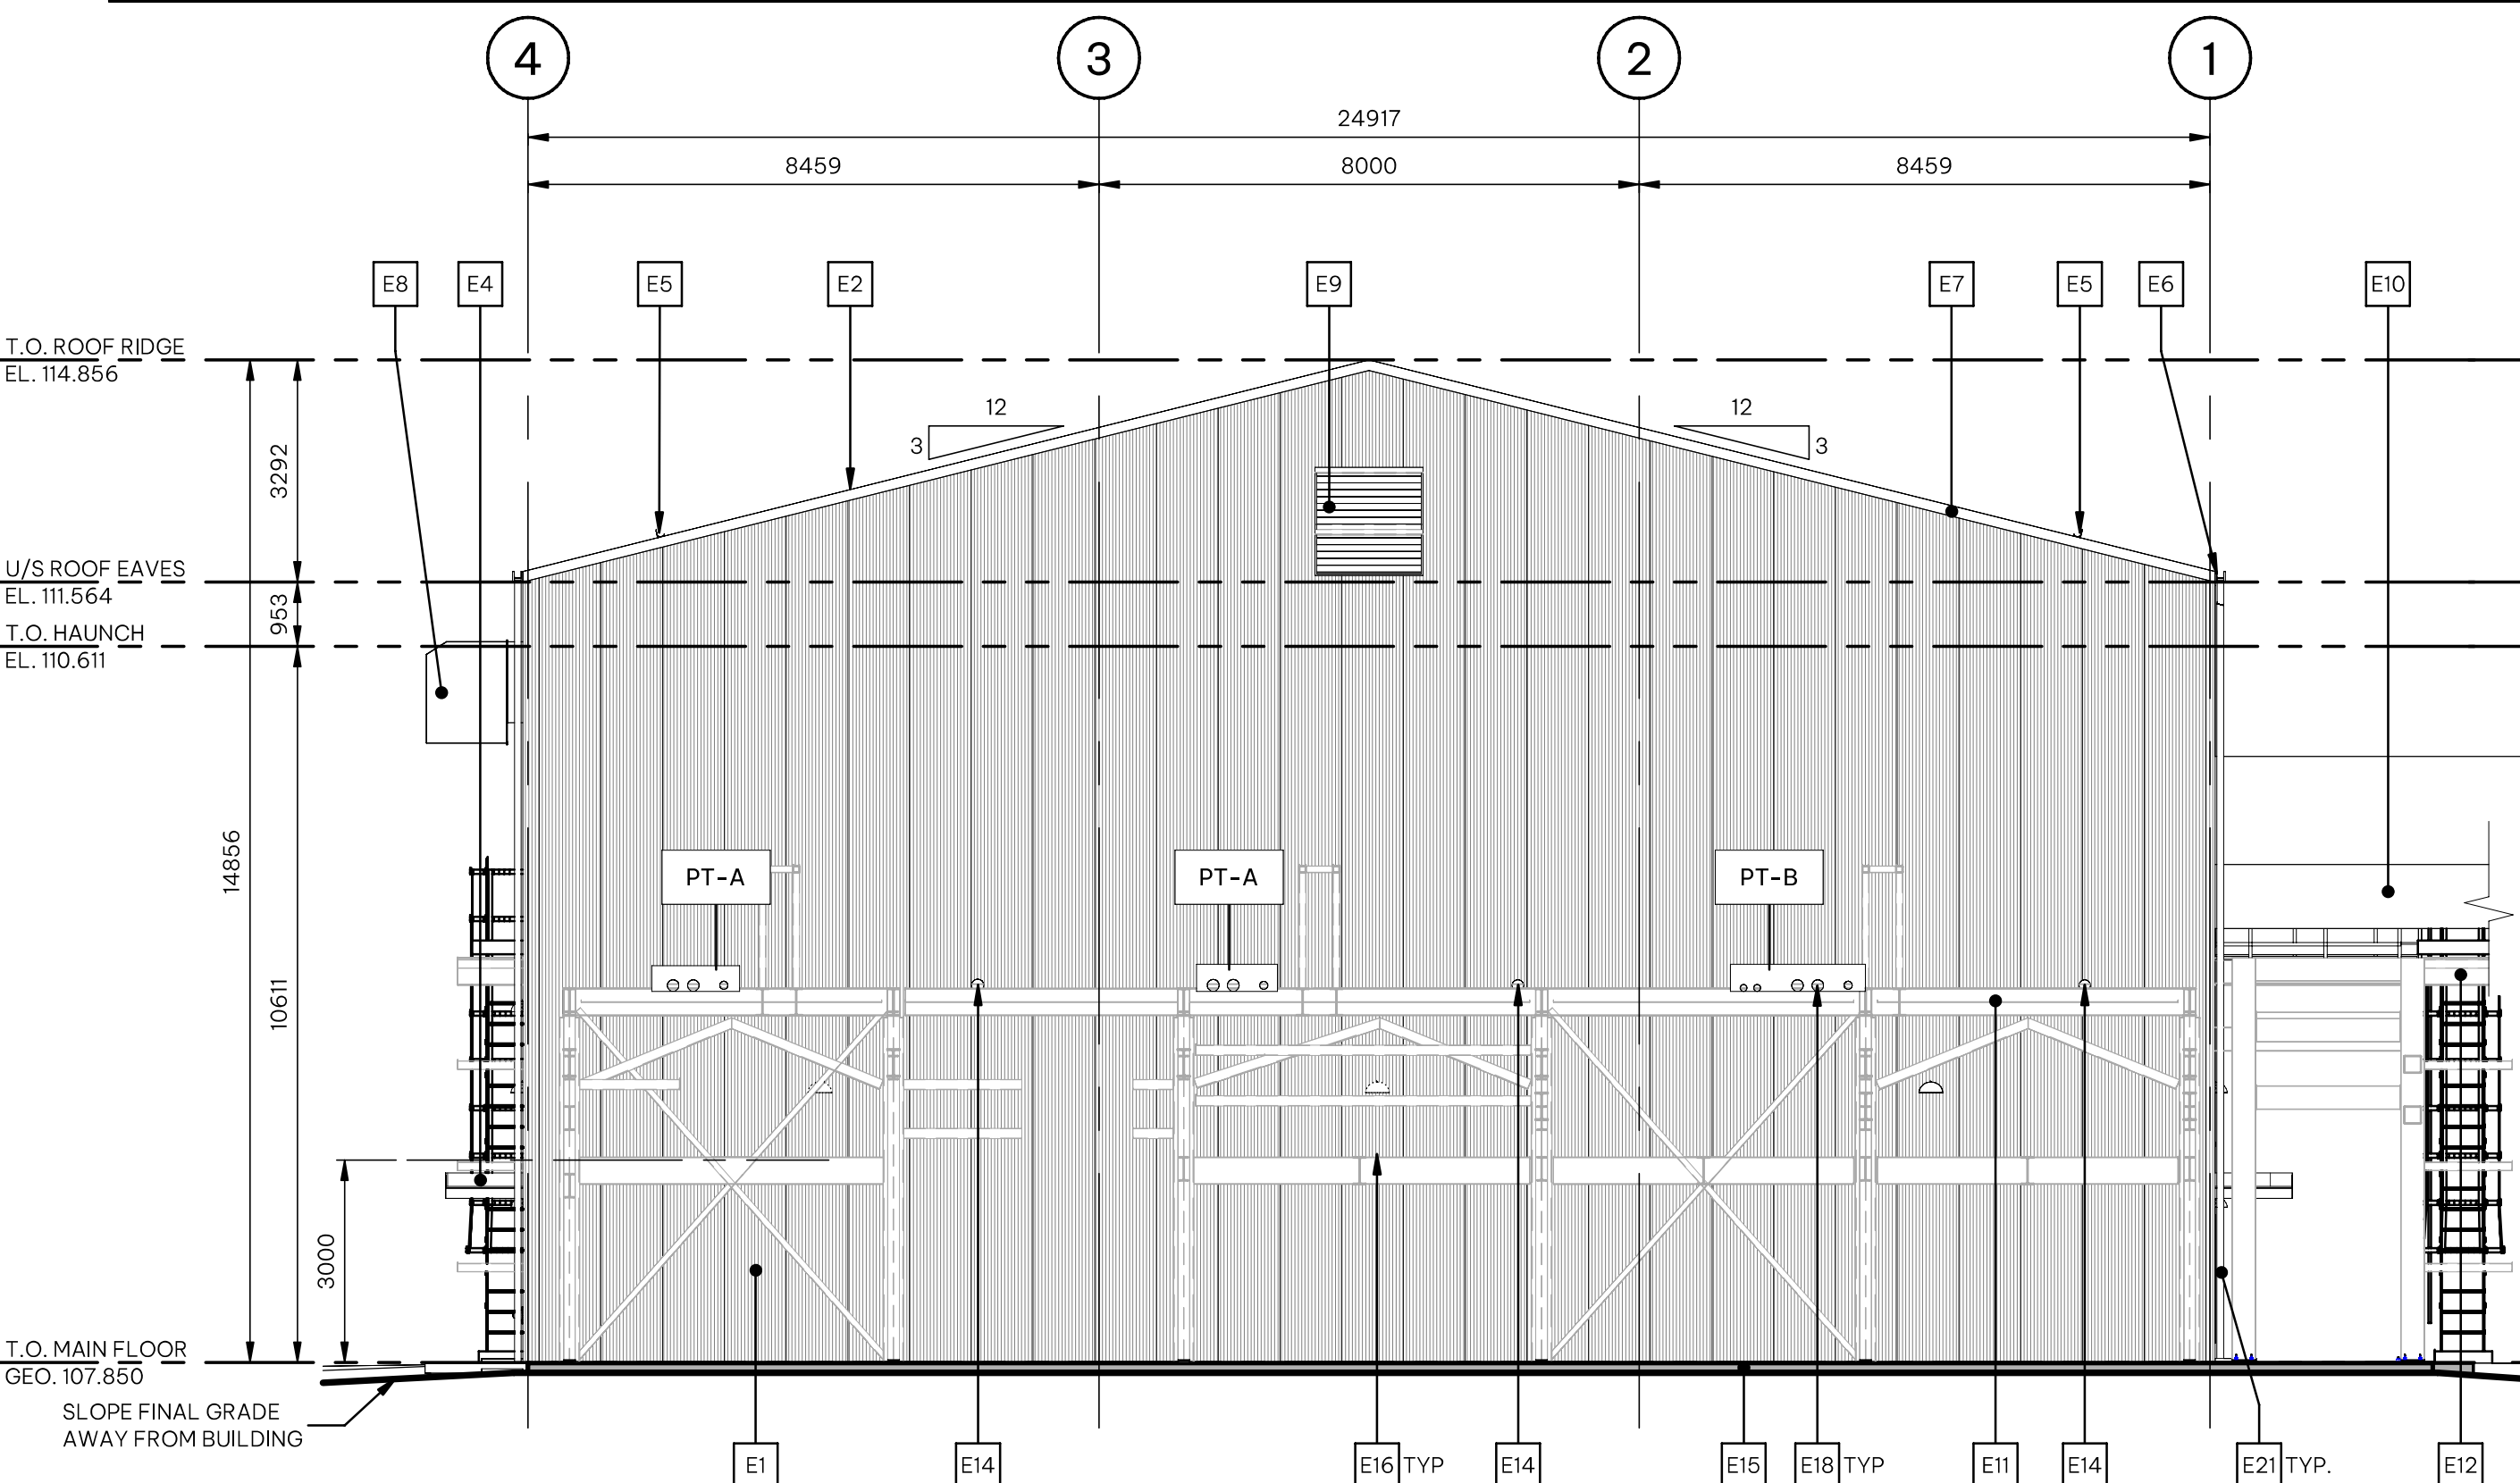


1 Instrument Air Building - North Elevation
110006 SCALE: 1 : 100

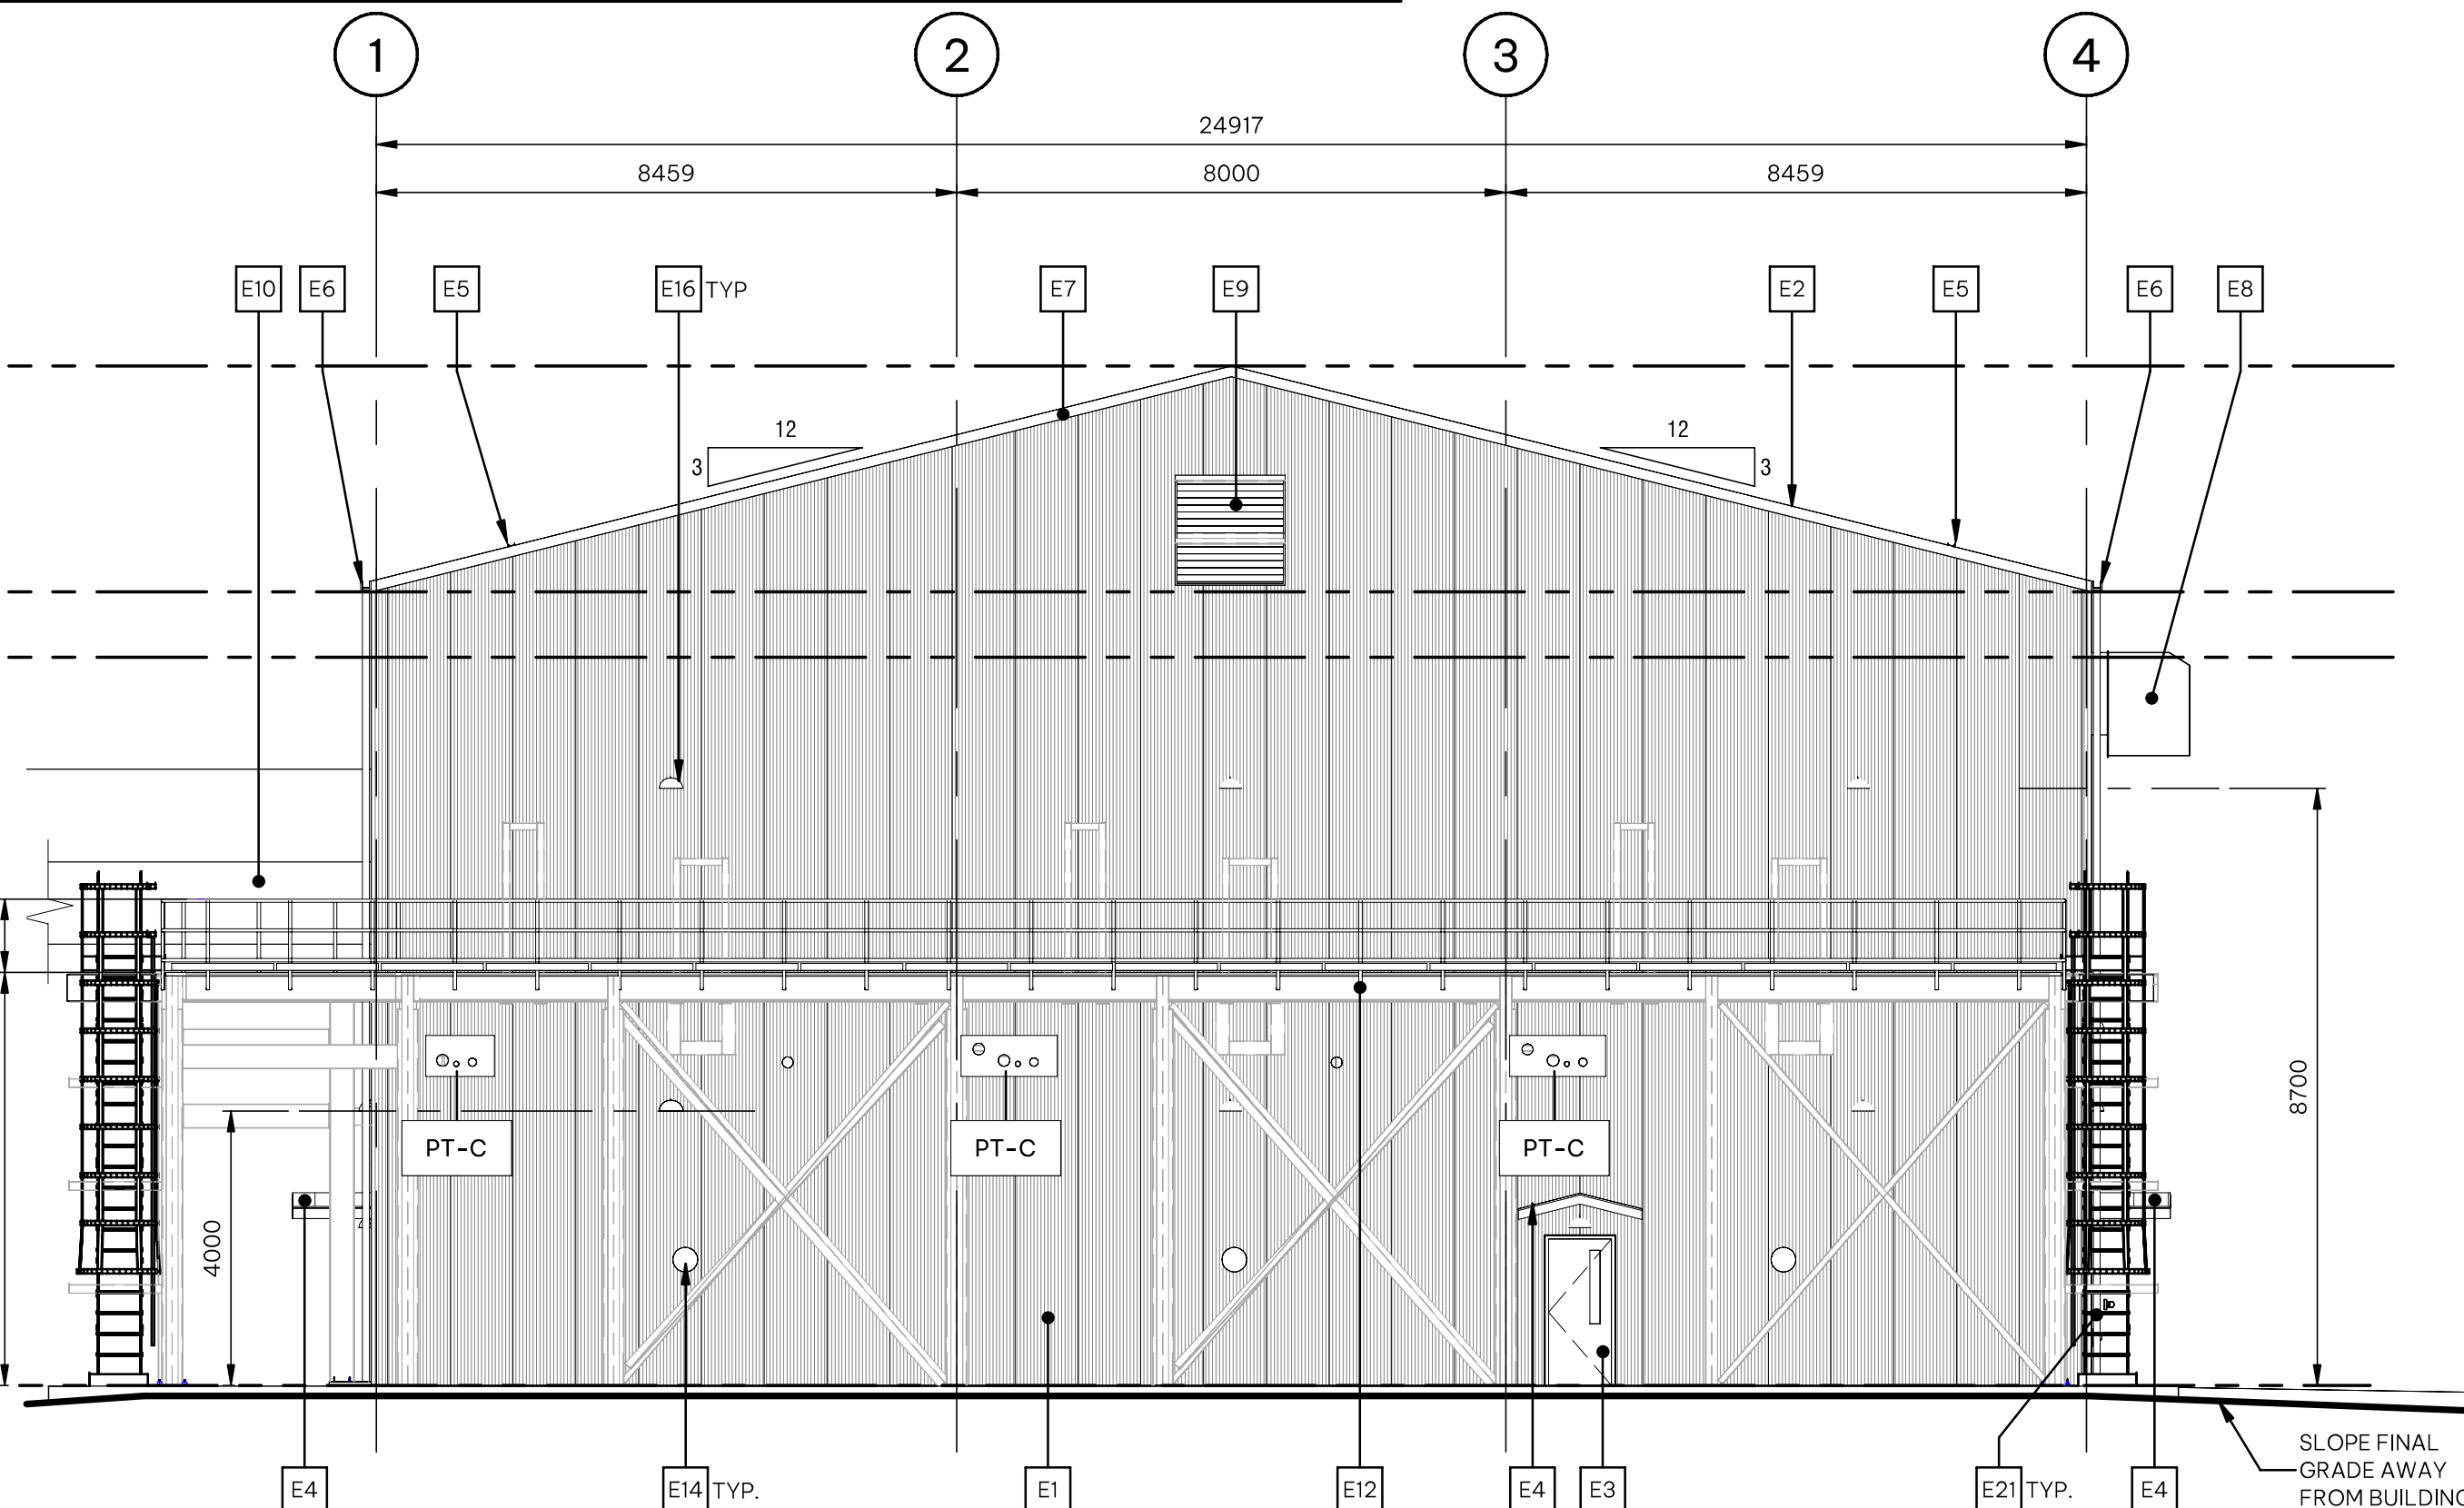

2 Instrument Air Building - South Elevation
110006 SCALE: 1 : 100

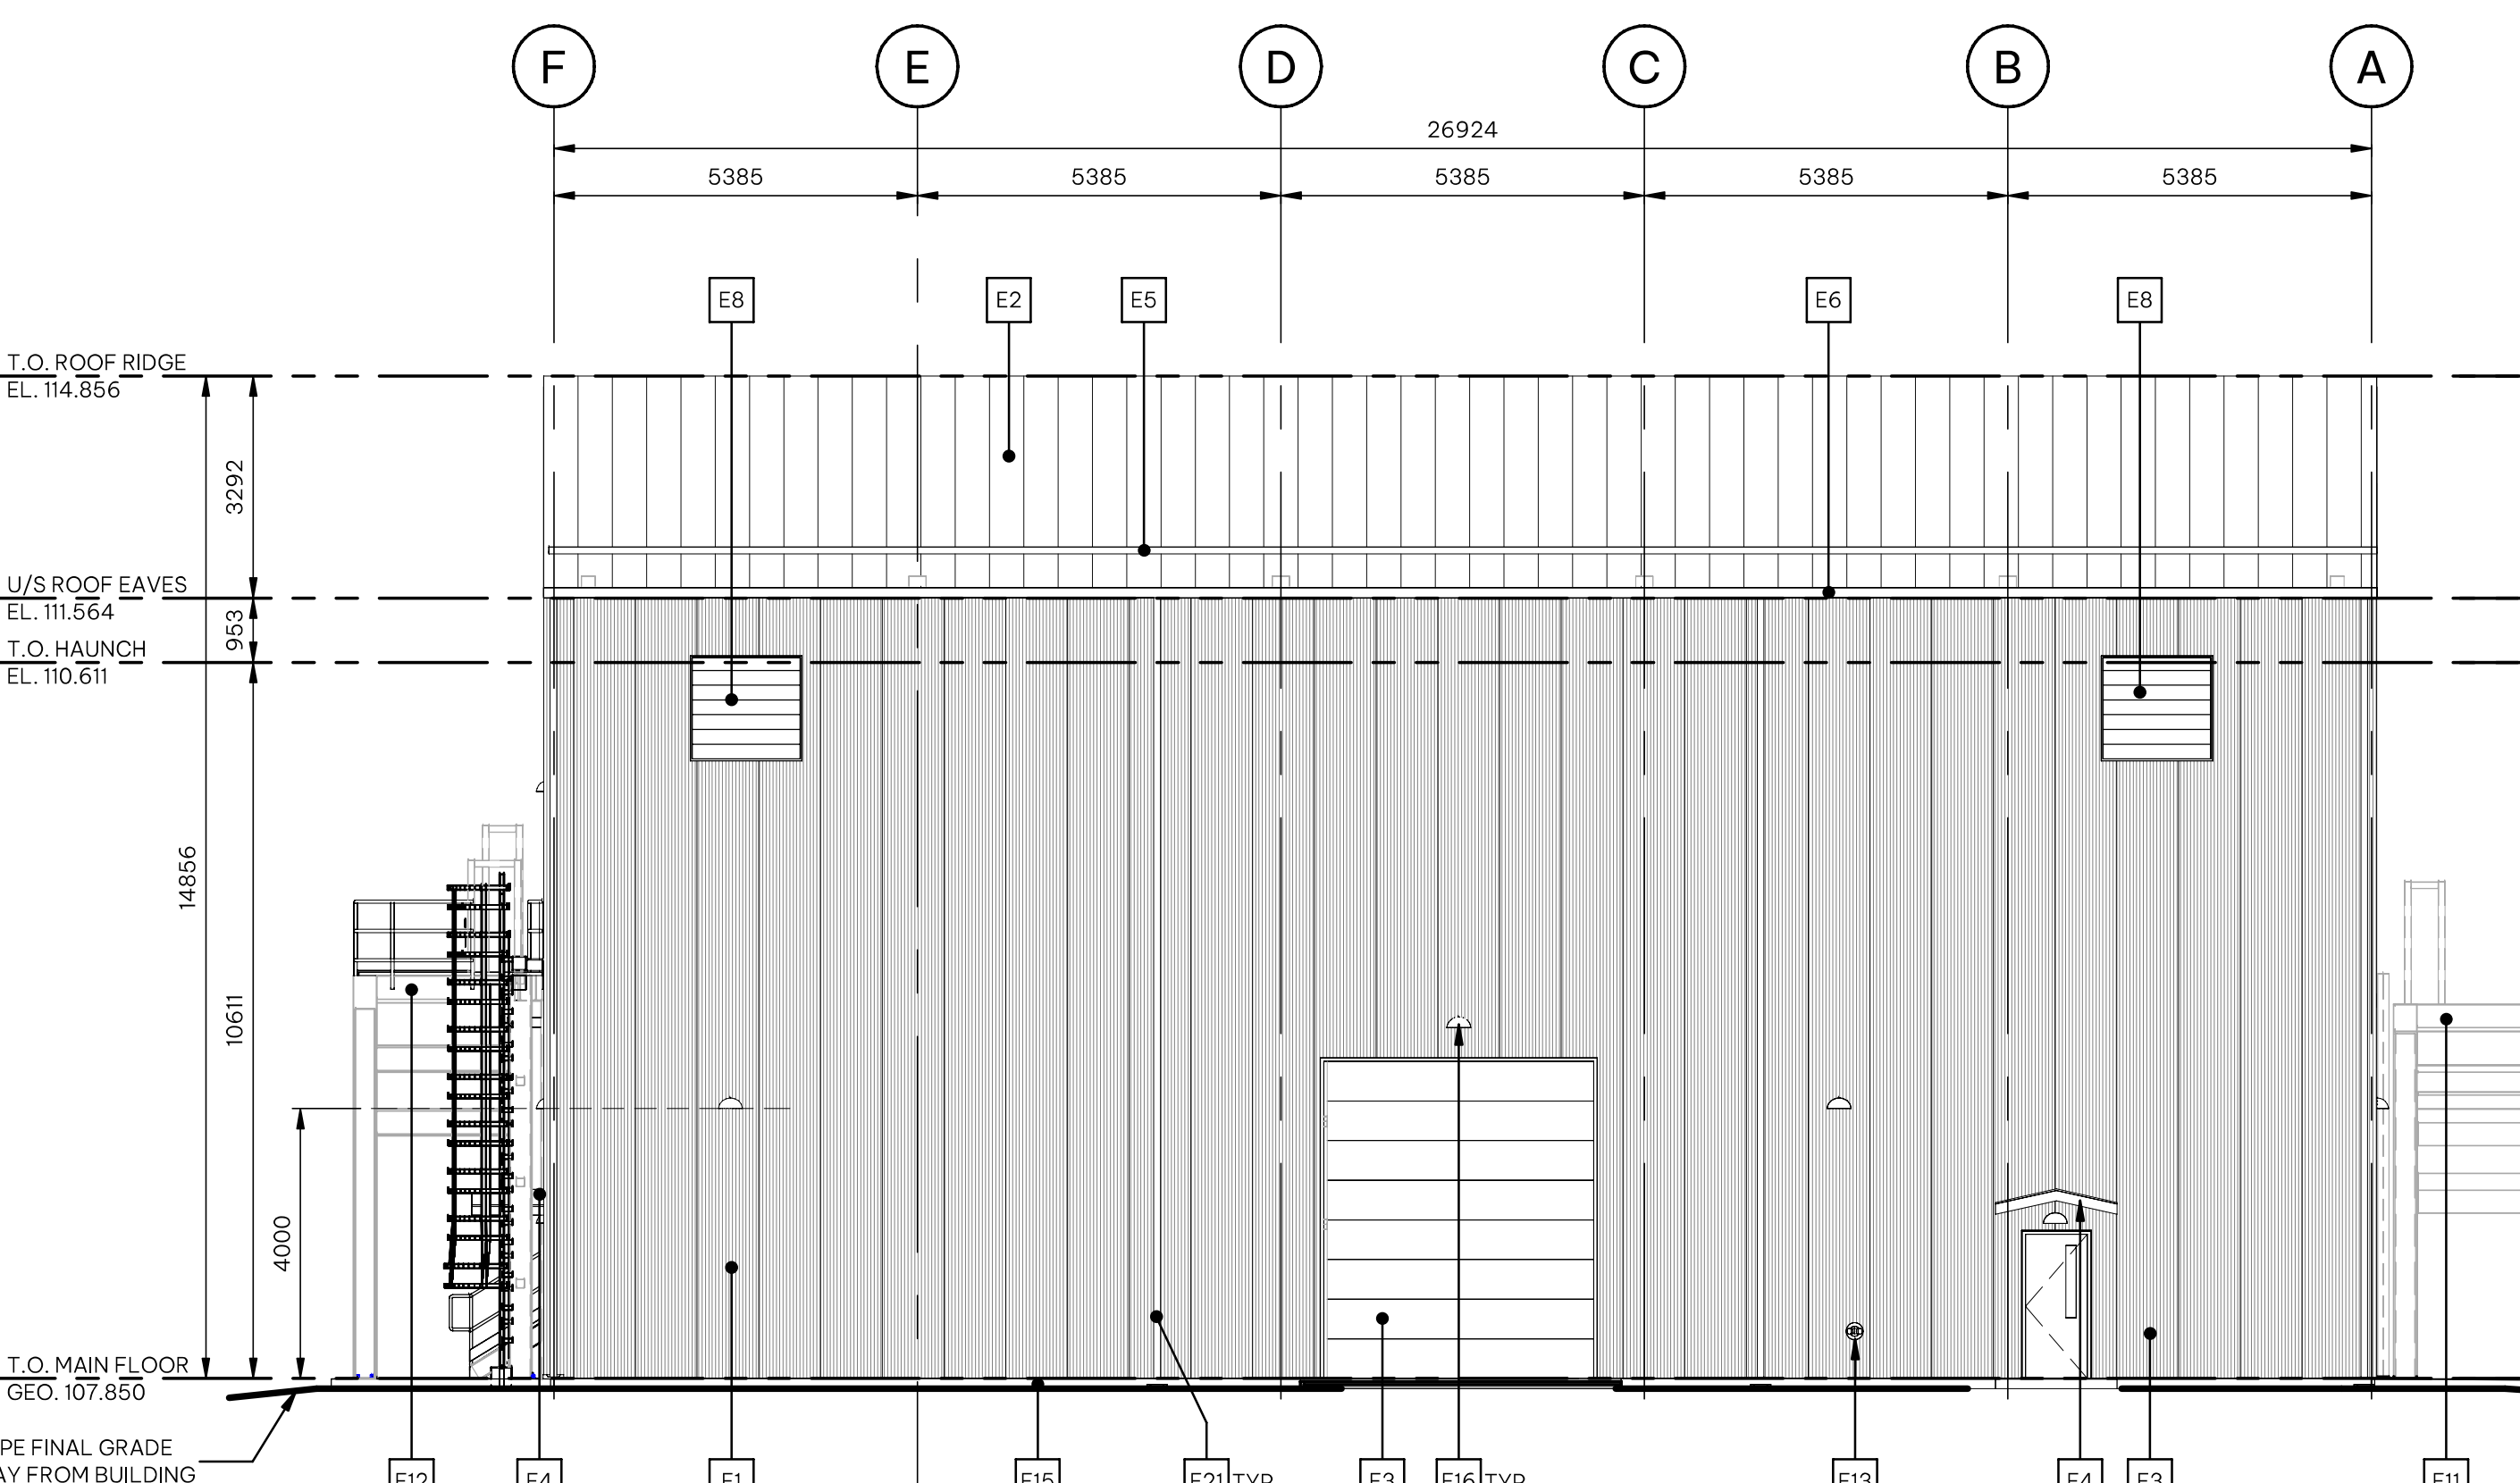

3 Instrument Air Building - East Elevation
110006 SCALE: 1 : 100

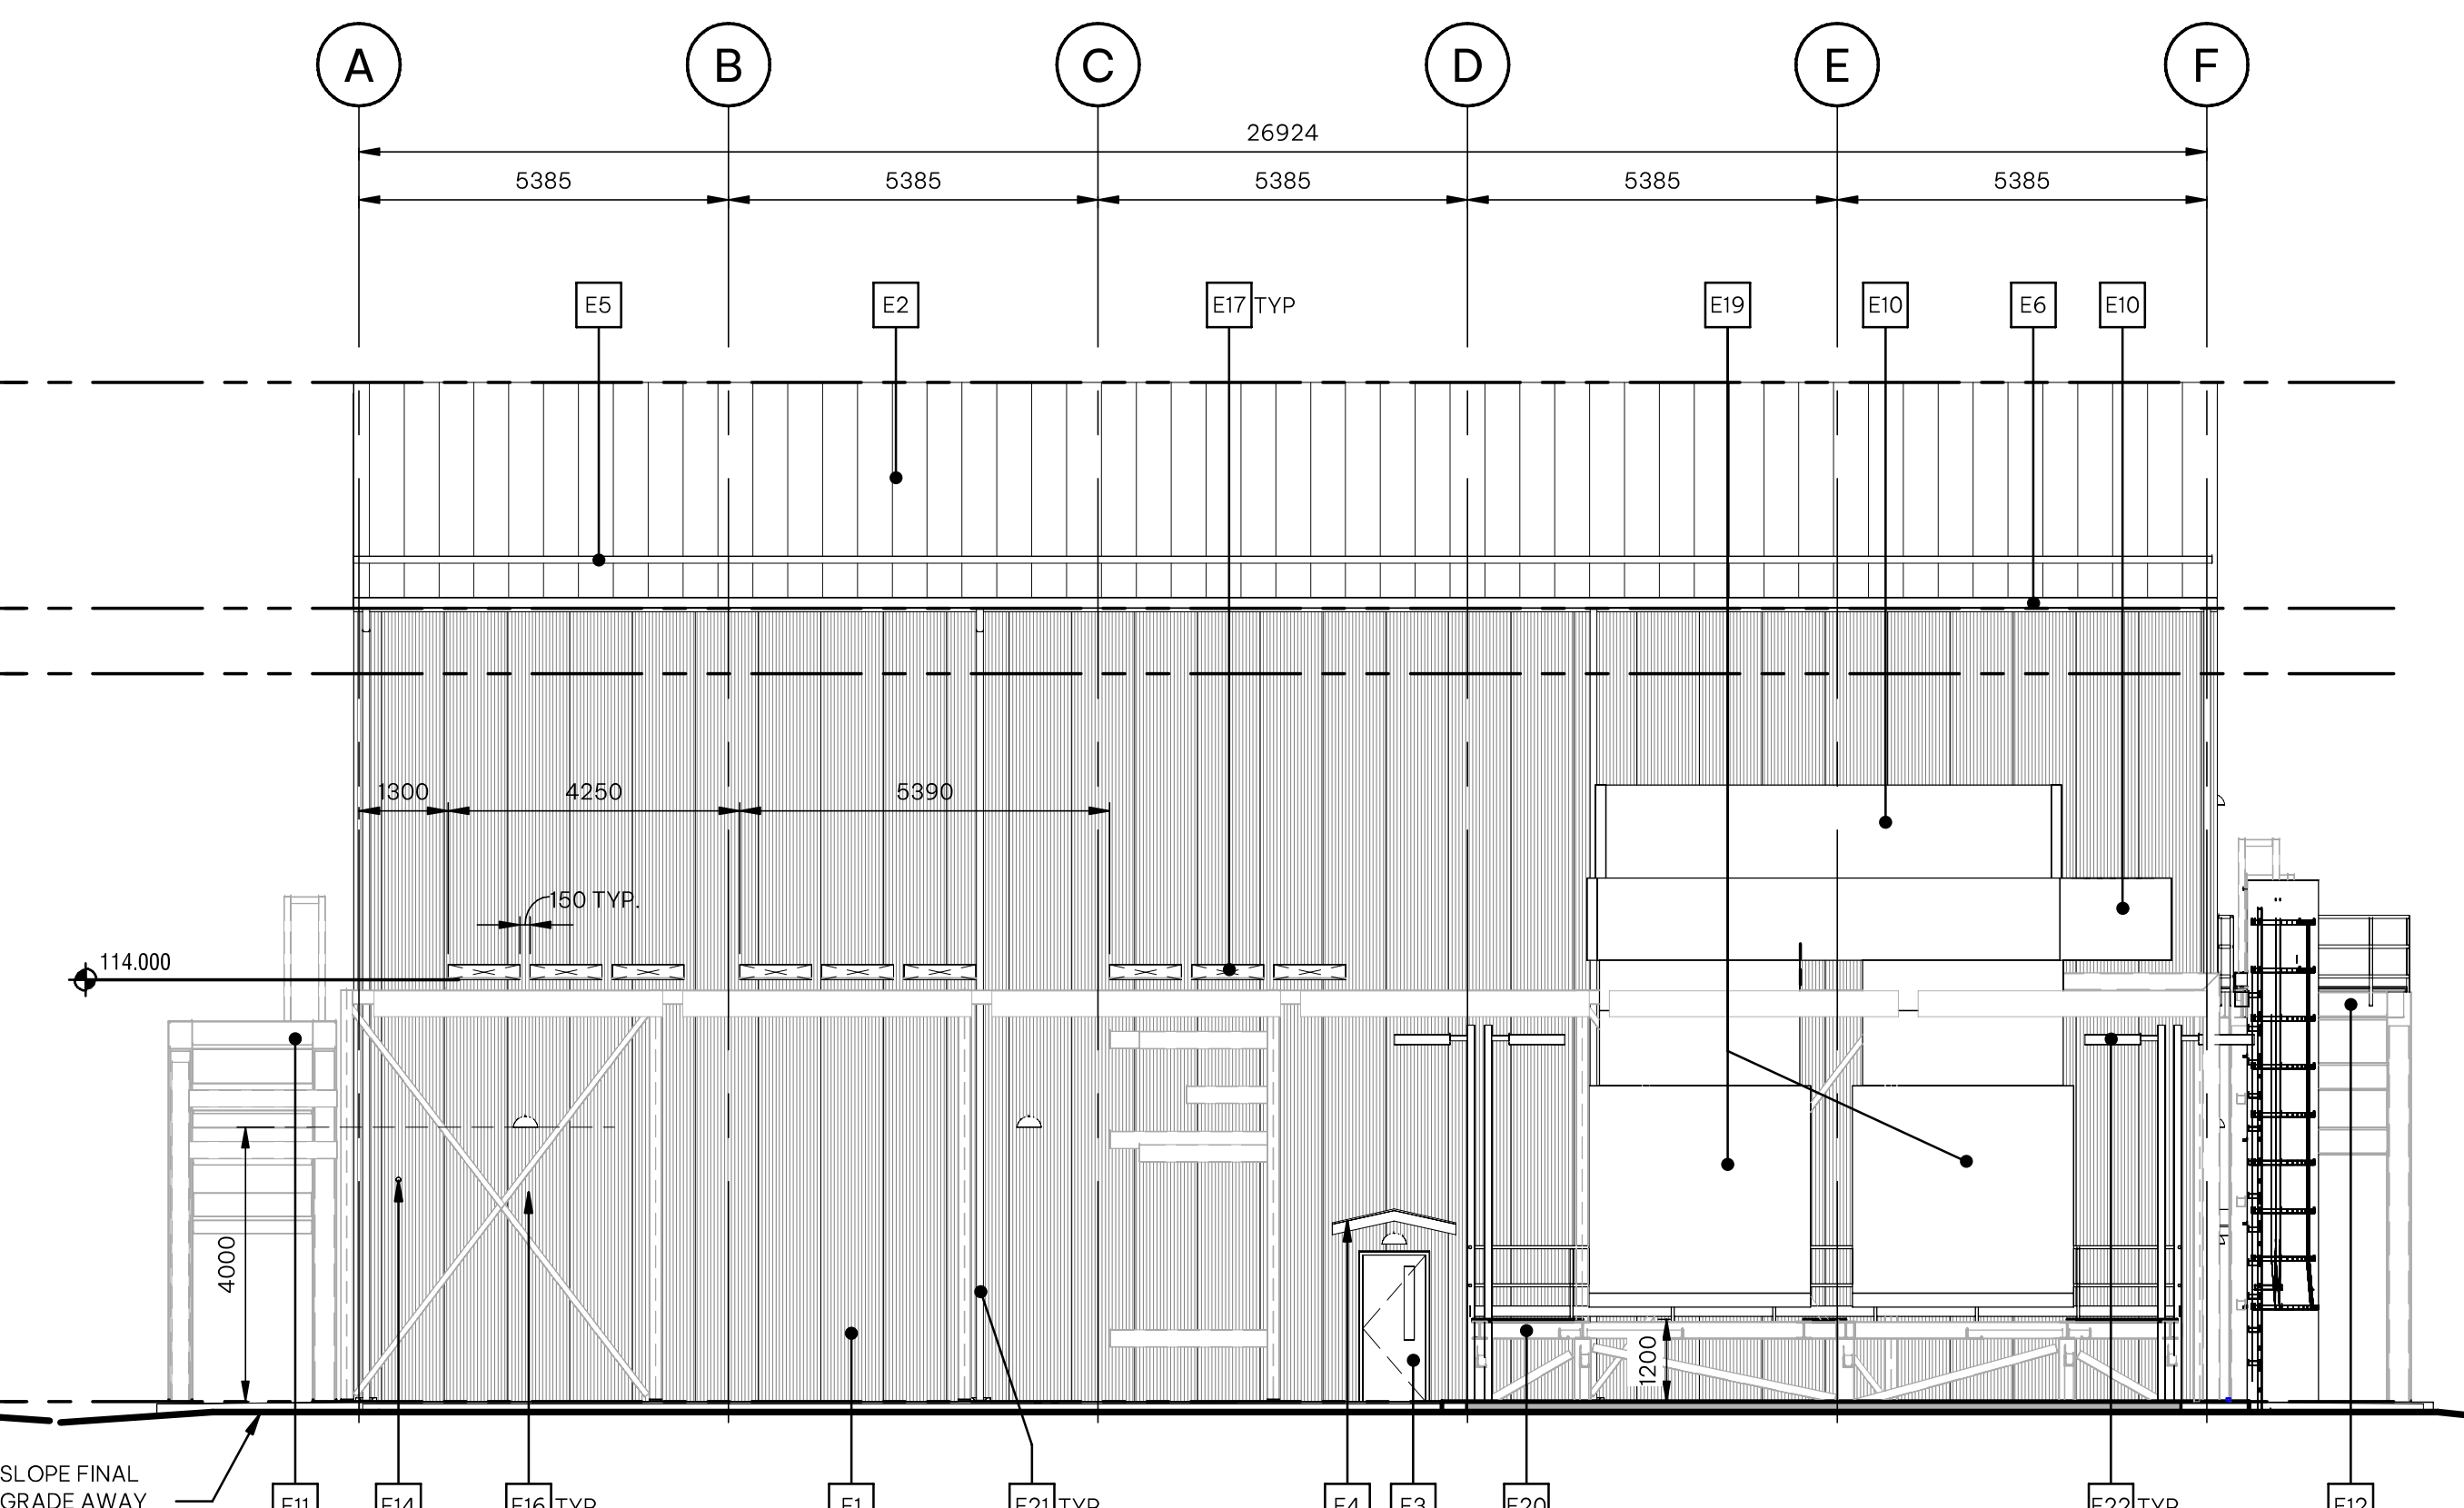

4 Instrument Air Building - West Elevation
110006 SCALE: 1 : 100

GENERAL NOTES:



- ALL DIMENSIONS ARE IN MILLIMETER, UNO.
- ALL DRAWING REFERENCE CALLOUTS ARE PREFIXED WITH 350106-SC-CV-001-SD, TYPICAL.

SHEET REFERENCES:

350106-SC-CV-001-SD-110001 - COVER SHEET
350106-SC-CV-001-SD-110004 - CONSTRUCTION ASSEMBLIES
350106-SC-CV-001-SD-110006 - MAIN FLOOR CONSTRUCTION PLAN
350106-SC-CV-001-SD-110007 - ROOF PLAN
350106-SC-CV-001-SD-110011 - MAIN FLOOR - SLAB PLAN

HOLDS:

		SUPPLIER/SUBCONTRACTOR DRAWING DECAL WOODFIBRE LNG			
Supplier Name: LBLNG					
SDR Code(s): F81,H81					
Equipment/Tag Number(s):					
Project Number	Purchase Order Number		Seq. No	Purchaser's Revision	
350106	SC-CV-001	SD	110010	2	
This document or drawing is the sole property and copyright of CB&I LLC and contains confidential and proprietary information. This document or drawing cannot be reproduced, copied, retained or used, in whole or in part, without written consent of CB&I LLC, a McDermott company.					
Form Number: CWS-670-02-FN-0006 Issued for Use: 21DEC2017					

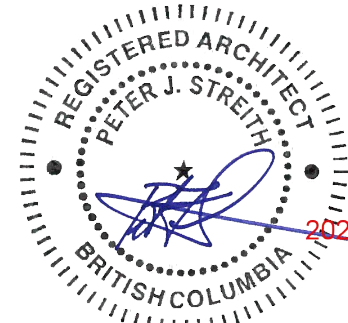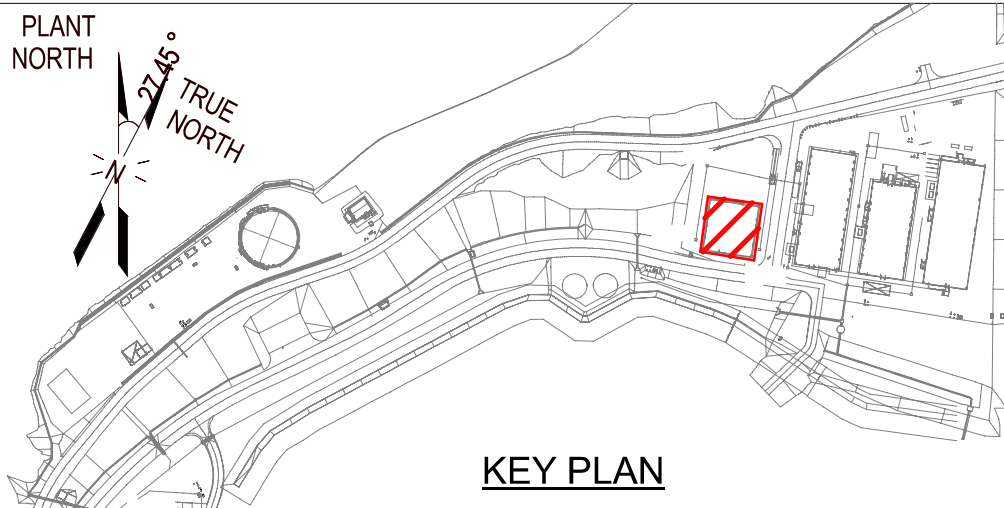

S2ARCHITECTURE
CALGARY | EDMONTON | VANCOUVER

B	ISSUED FOR BUILDING PERMIT	DE	PS	GW	2025FEB13
A	ISSUED FOR 30% FORMAL REVIEW	DE	PS	GW	2024NOV08
NO.	REVISION	DRWN	CK'D	APPD	DATE

MCDERMOTT

THIS DOCUMENT OR DRAWING IS THE SOLE PROPERTY AND COPYRIGHT OF CB&I LLC, A MCDERMOTT COMPANY, AND CONTAINS CONFIDENTIAL AND PROPRIETARY INFORMATION. THIS DOCUMENT OR DRAWING CANNOT BE REPRODUCED, COPIED, RETAINED OR USED, IN WHOLE OR IN PART, WITHOUT WRITTEN CONSENT OF CB&I LLC.

Drawn By	Drwn Date	Chkd By	Chkd Date	Aprvd By	Aprvd Date	Scale
DE	2025FEB13	PS	2025FEB13	GW	2025FEB13	AS NOTED



Woodfibre LNG Project


CLIENT DWG NO:

INDUSTRIAL AREA
01-BLG-0011-INSTRUMENT AIR COMPRESSOR BUILDING
BUILDING SECTIONS
ARCHITECTURAL


FOR:

Woodfibre LNG Limited


PROJ. NO:	DWG NO:	REV:
350106	350106-SC-CV-001-SD-110010	B

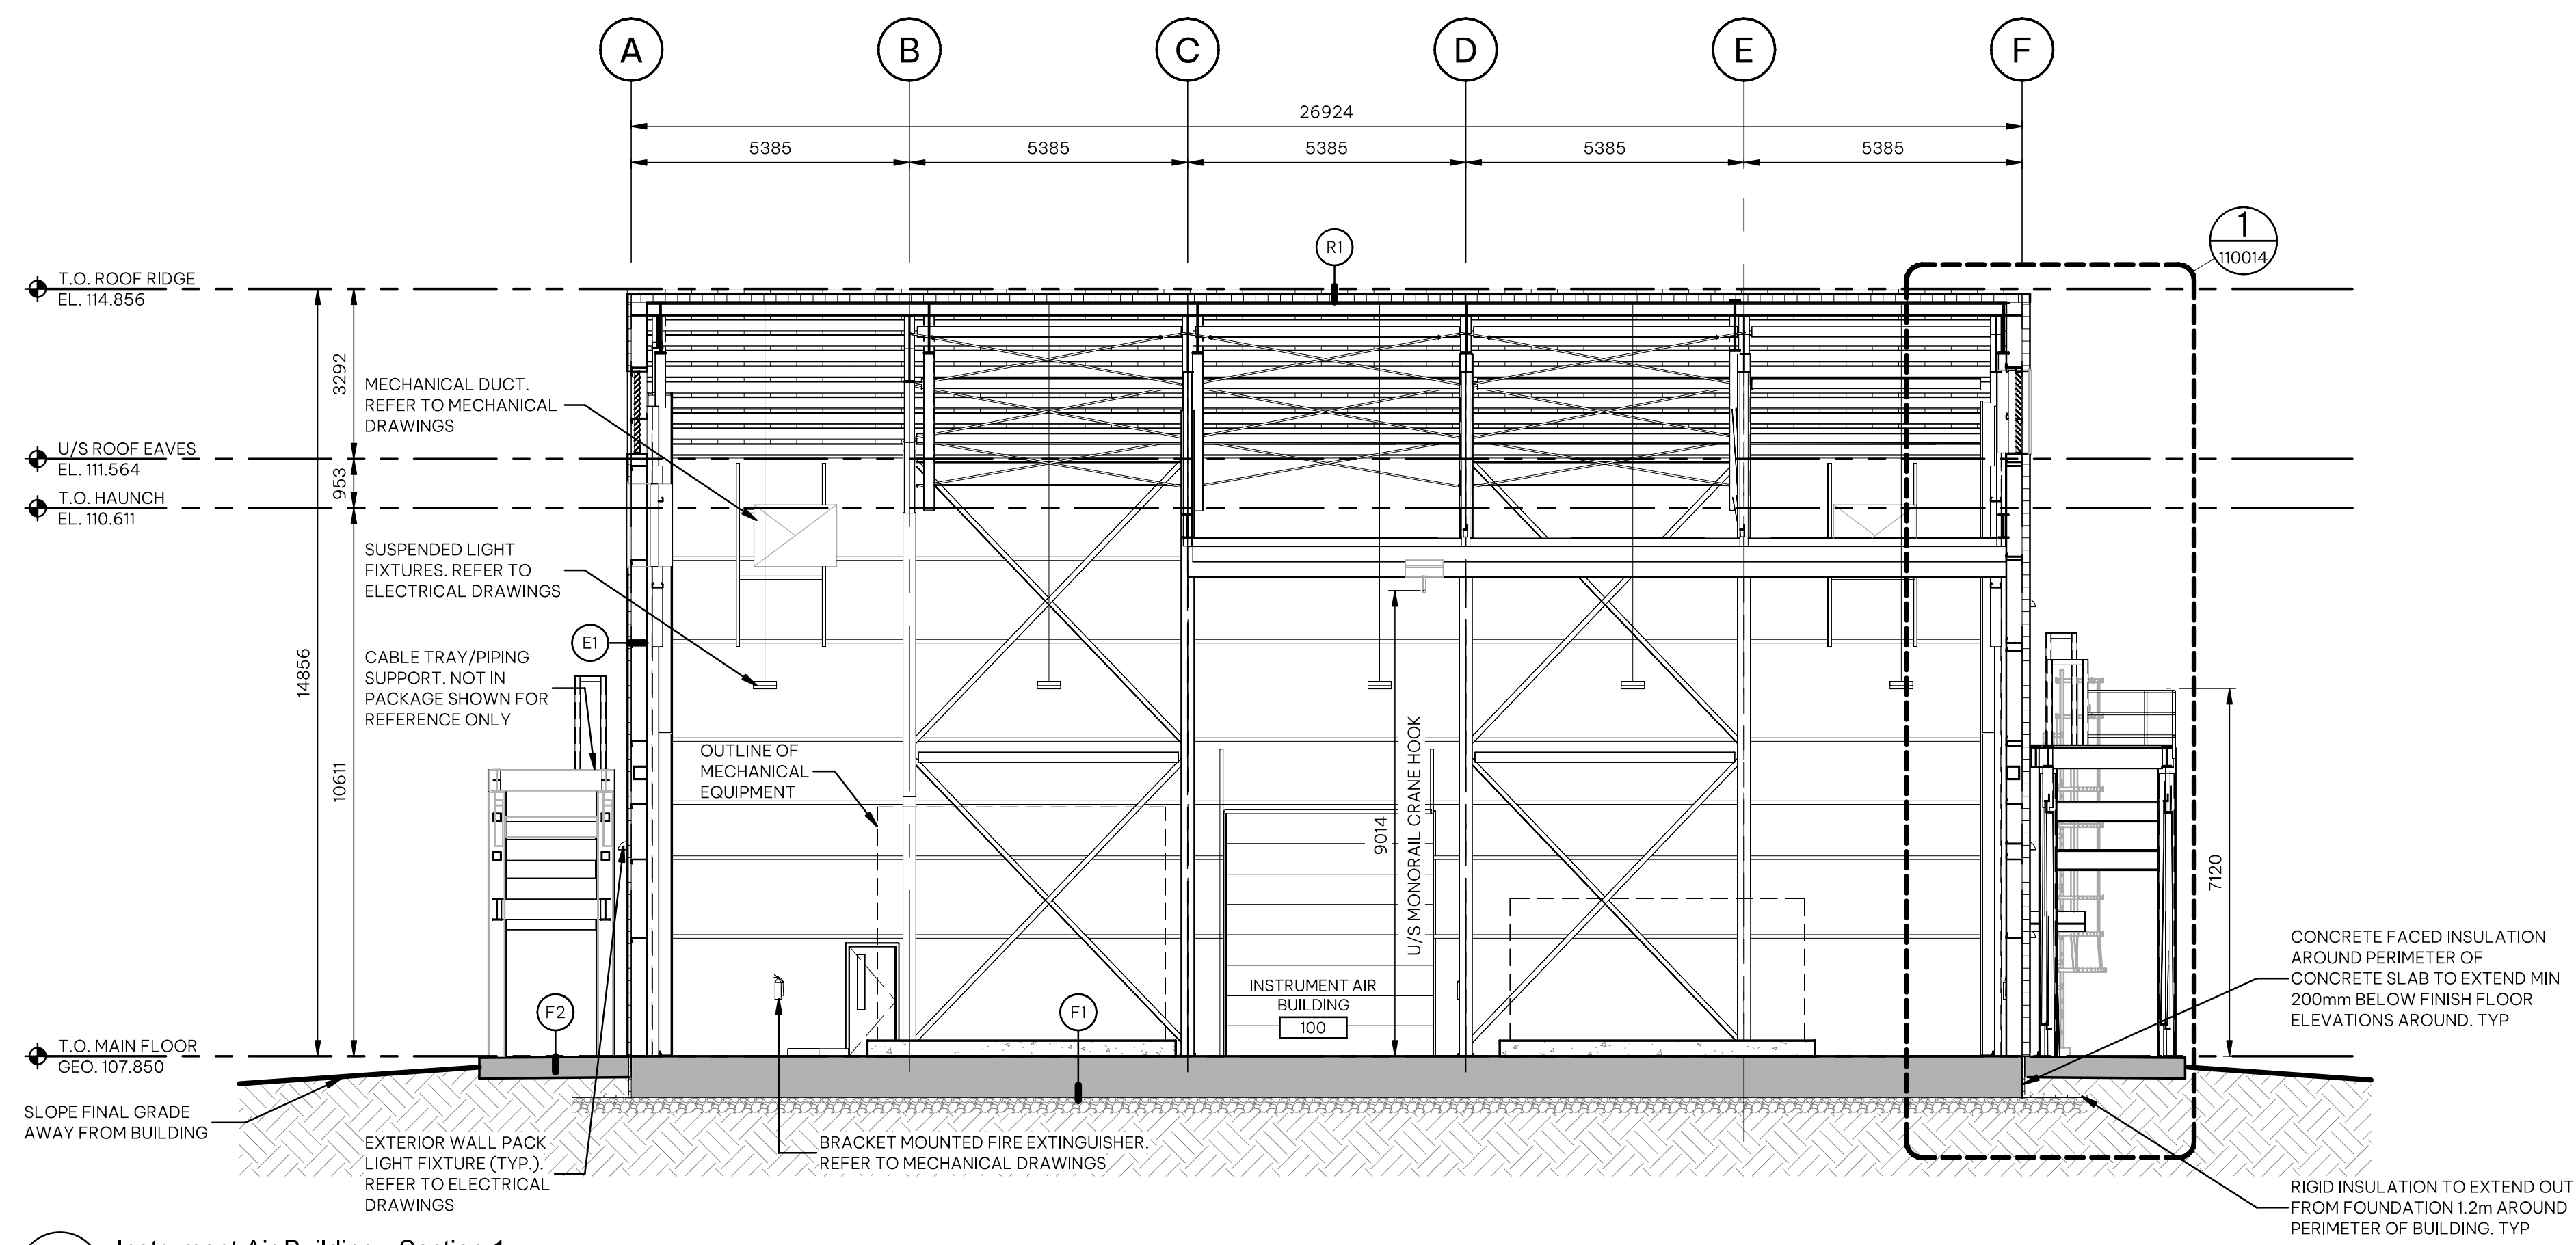

1 Instrument Air Building - Section 1
110006 SCALE: 1 : 100

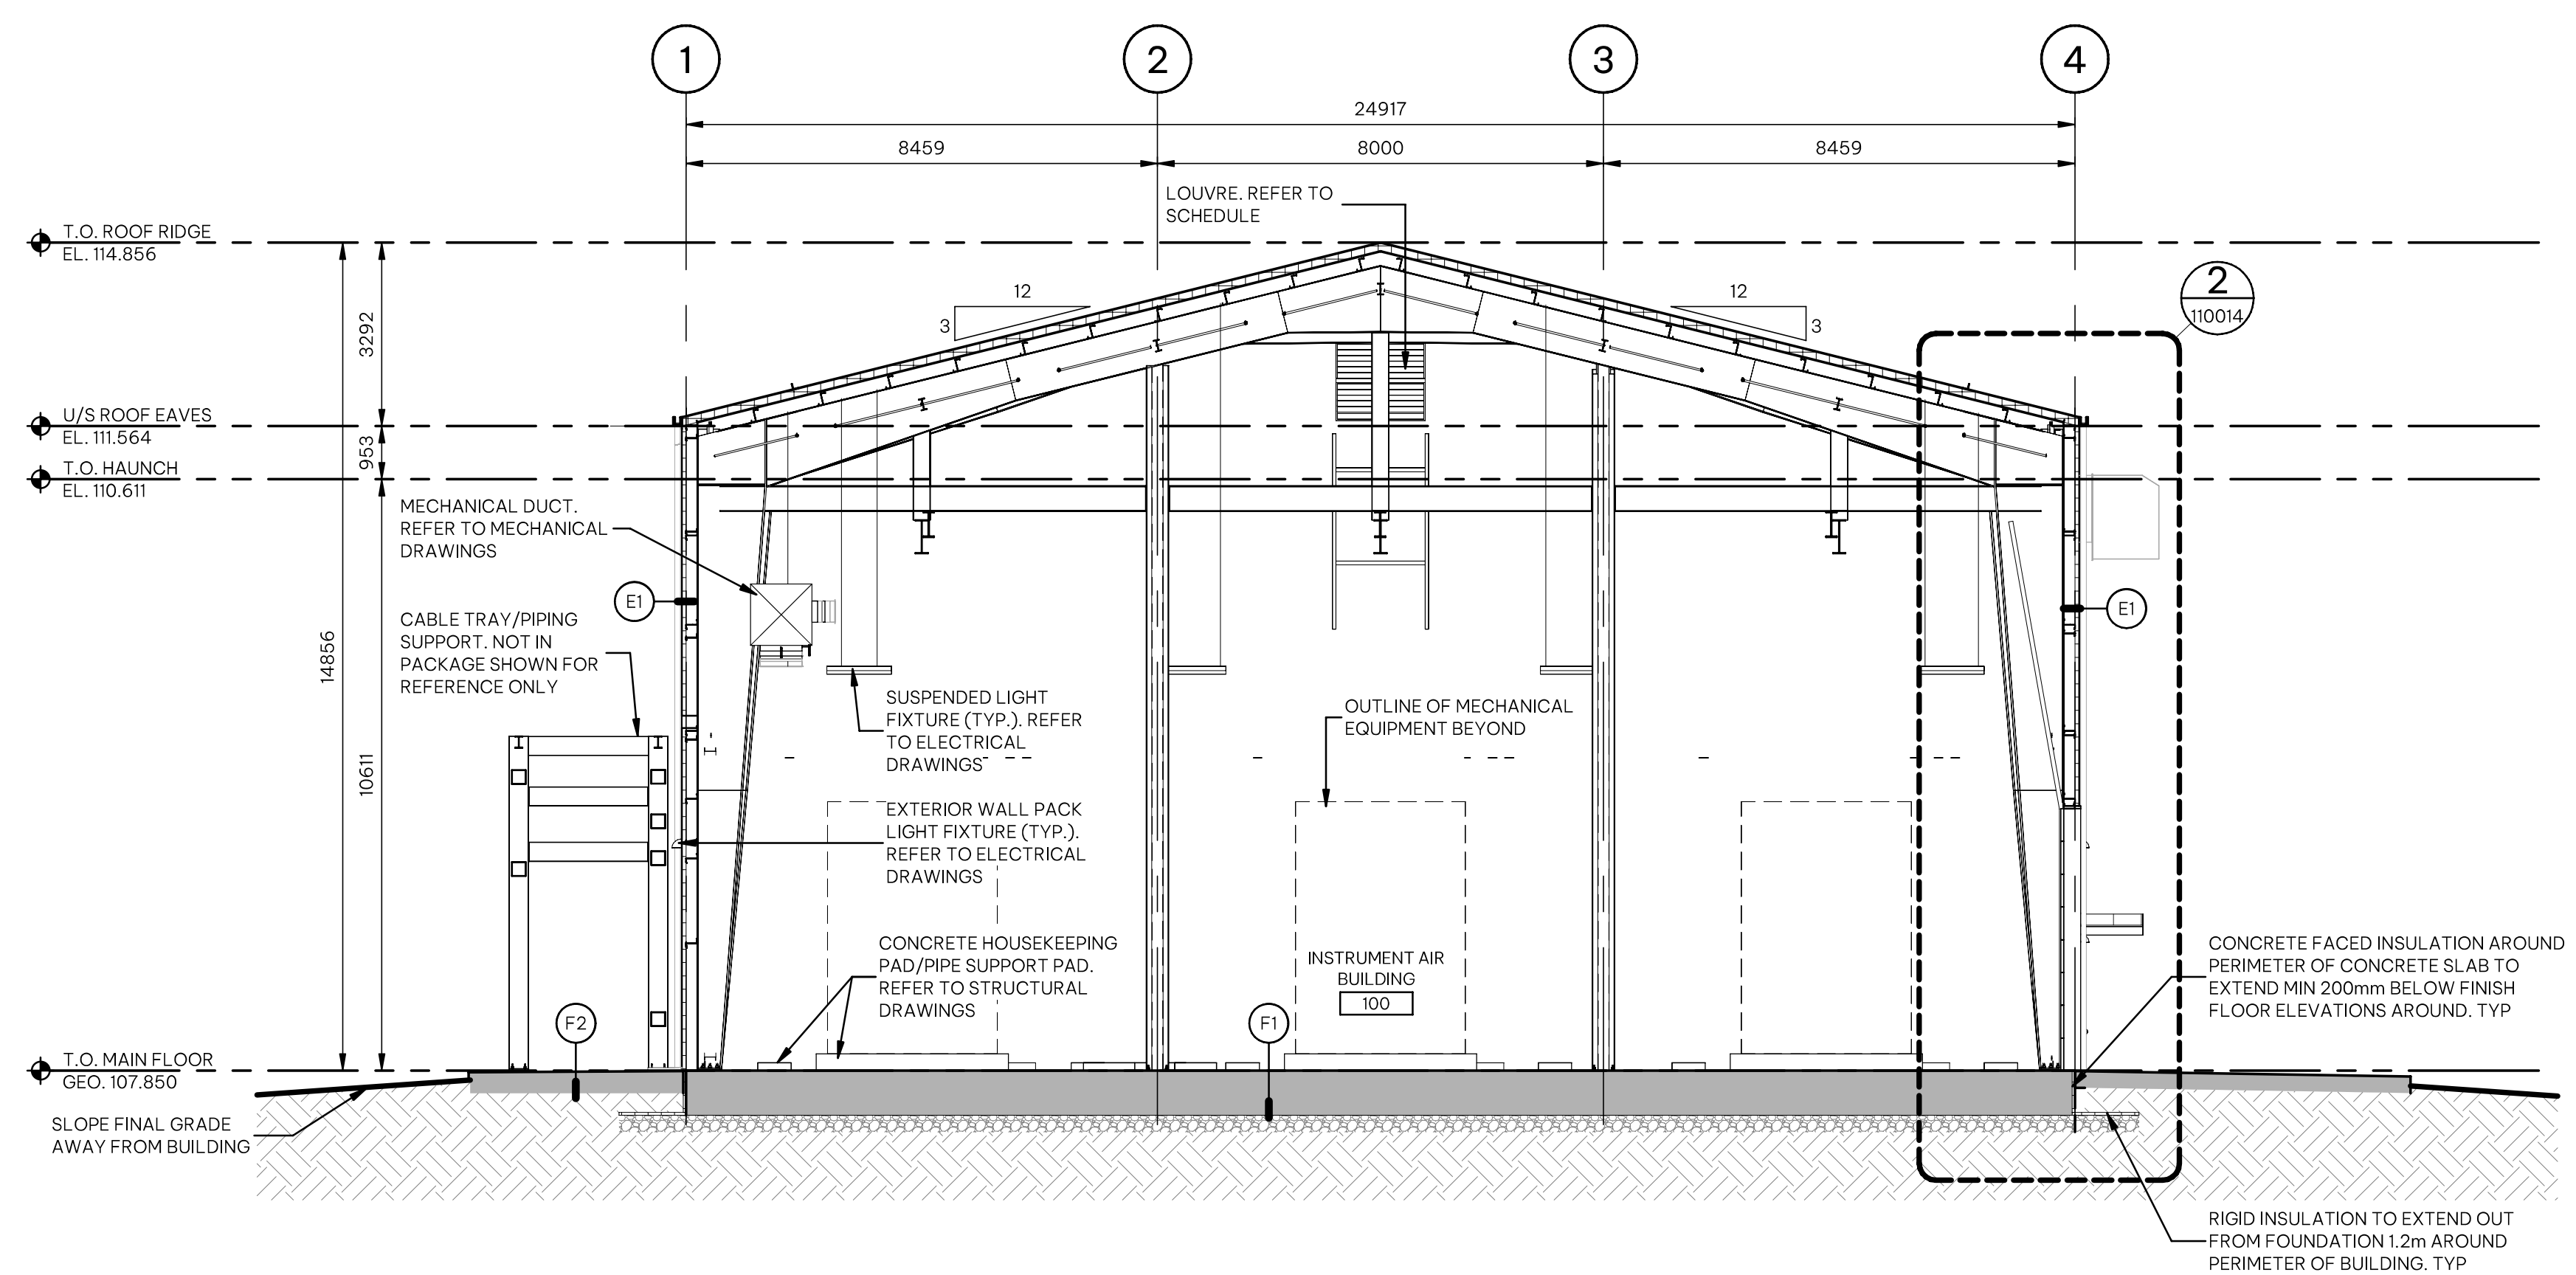

2 Instrument Air Building - Section 2
110006 SCALE: 1 : 100

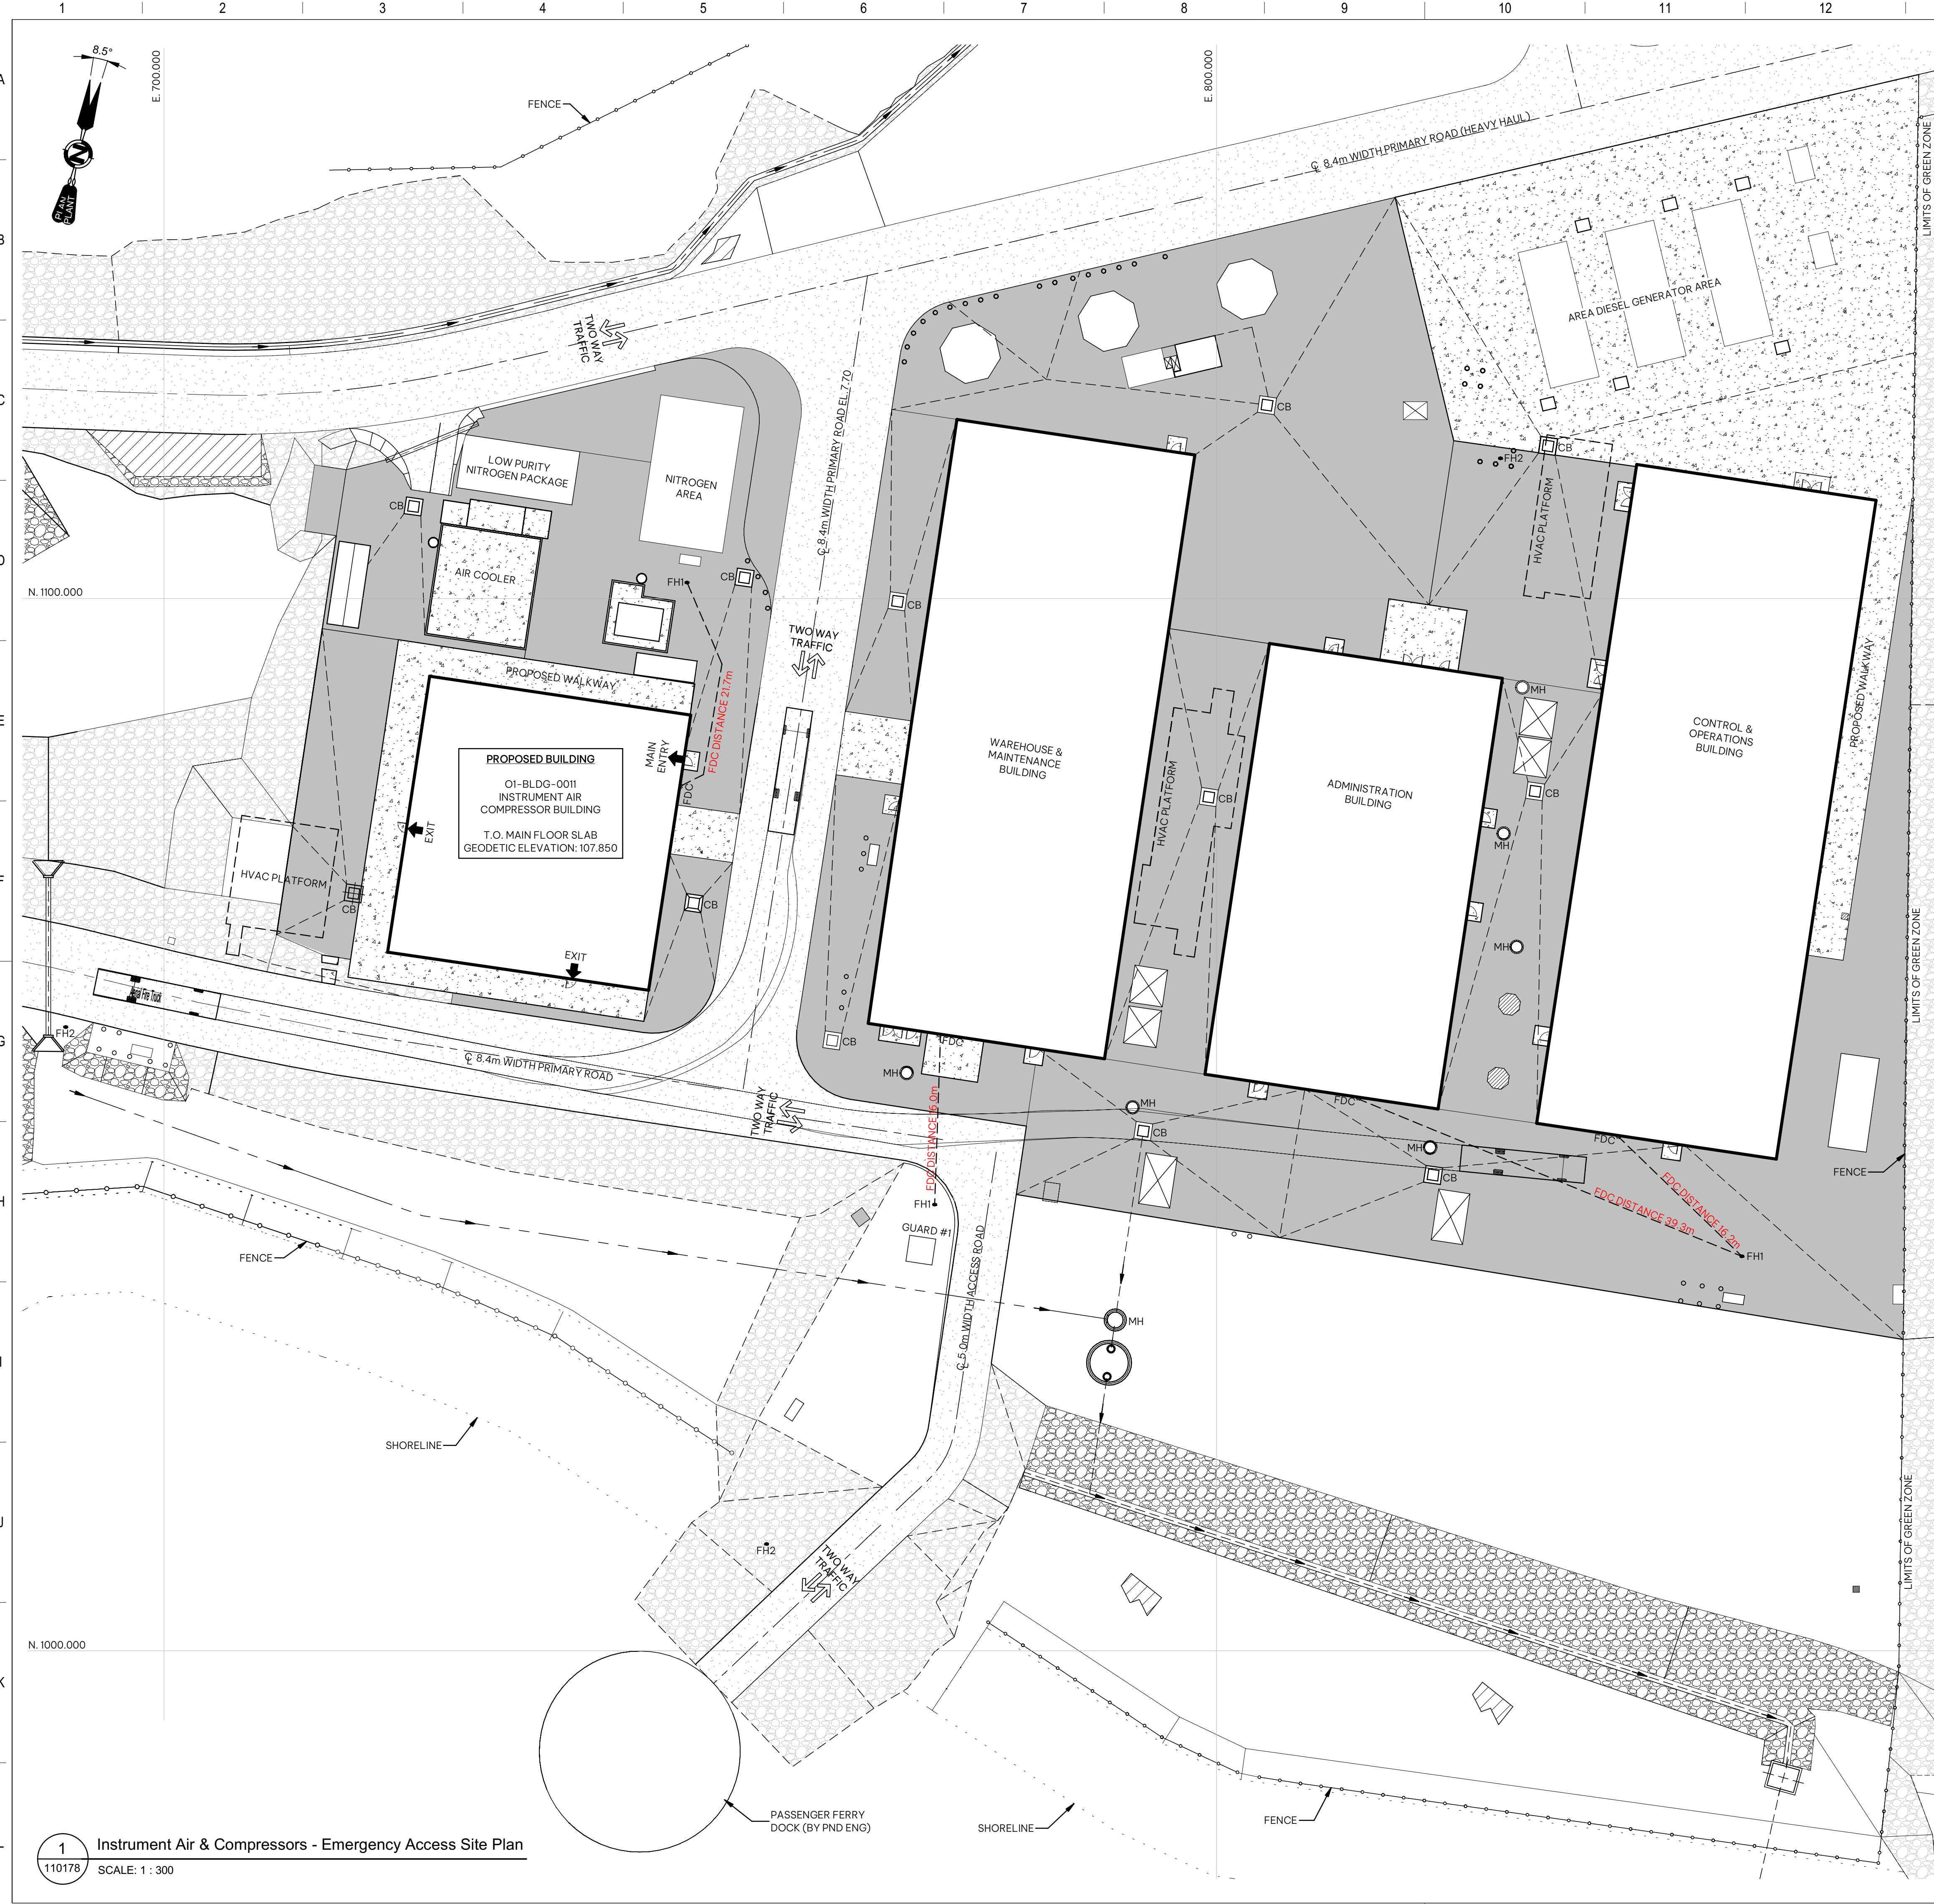


Access Route - General Notes

1. THIS DRAWING SHALL BE READ IN CONJUNCTION WITH CIVIL, LANDSCAPE, MECHANICAL AND ELECTRICAL DRAWINGS AND SPECIFICATIONS. ALL WORK TO BE COORDINATED AND VERIFIED PRIOR TO CONSTRUCTION.

Access Route - Symbol Legend

- INDICATES EXTENT AND LOCATION OF ASPHALT. REFER TO CIVIL DRAWINGS.
- INDICATES EXTENT AND LOCATION OF GRAVEL. REFER TO CIVIL DRAWINGS.
- INDICATES EXTENT AND LOCATION OF CONCRETE PAVING. REFER TO CIVIL DRAWINGS.
- INDICATES EXTENT AND LOCATION OF RIPRAP. REFER TO CIVIL DRAWINGS.
- INDICATES EXTENT AND LOCATION OF EXISTING ASPHALT. (COMPLETED RG-PCKG A)
- INDICATES EXTENT AND LOCATION OF EXISTING RIPRAP. (COMPLETED RG-PCKG A)
- INDICATES EXTENT AND LOCATION OF EXISTING GRAVEL ROAD. (COMPLETED RG-PCKG A)
- ELECTRICAL, MECHANICAL, TELECOM SCOPE
- INDICATES LOCATION OF CATCH BASIN. REFER TO CIVIL DRAWINGS.
- INDICATES LOCATION OF MANHOLE. REFER TO CIVIL DRAWINGS.
- INDICATES LOCATION OF FIRE HYDRANT. REFER TO CIVIL DRAWINGS.
- INDICATES LOCATION OF REMOTE ACTUATED FIRE HYDRANT. REFER TO CIVIL DRAWINGS.
- INDICATES LOCATION OF FIRE DEPARTMENT CONNECTION. REFER TO MECHANICAL DRAWINGS.
- INDICATES SECURITY FENCE. REFER TO CIVIL DRAWINGS.
- INDICATES PEDESTAL. REFER TO CIVIL DRAWINGS.

Building Height Elevation

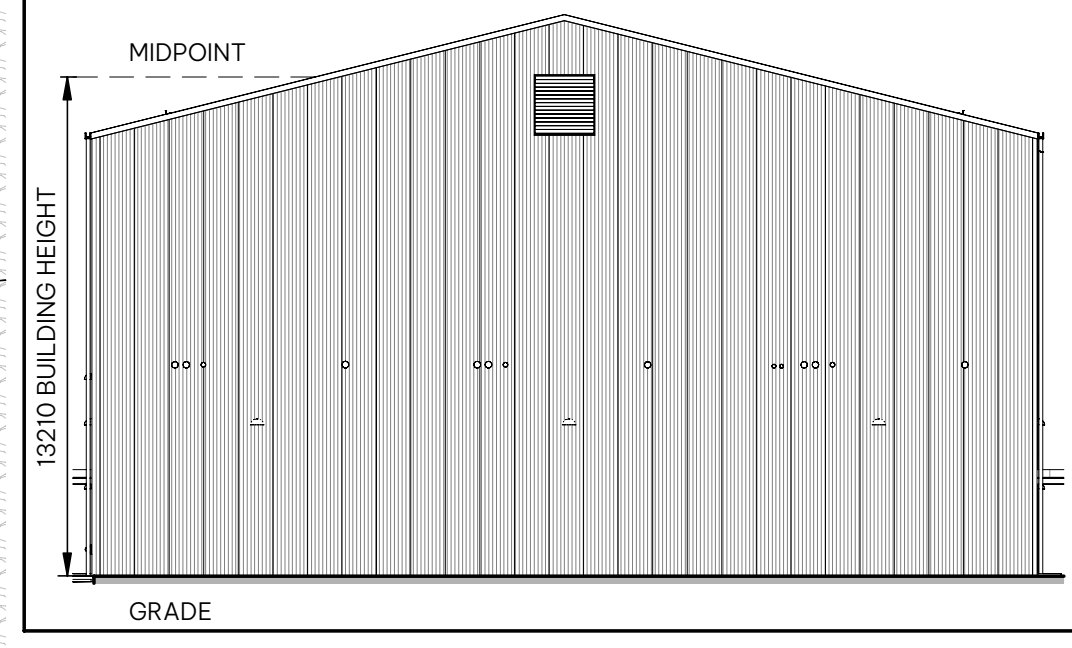

GENERAL NOTES:

1. ALL DIMENSIONS ARE IN MILLIMETER, UNO.
2. ALL DRAWING REFERENCE CALLOUTS ARE PREFIXED WITH 350106-SC-CV-001-SD, TYPICAL.

SHEET REFERENCES:

350106-SC-CV-001-SD-110001 - COVER SHEET
350106-SC-CV-001-SD-110179 - GRADING SITE PLAN

HOLDS:

	SUPPLIER/SUBCONTRACTOR DRAWING DECAL WOODFIBRE LNG	
Supplier Name: LBLNG		
SDR Code(s): E05		
Equipment/Tag Number(s):		
Project Number 350106	Purchase Order Number SC-CV-001	Seq No SD
		Purchaser's Revision 110178 2

This document or drawing is the sole property and copyright of CB&I LLC and contains confidential and proprietary information. This document or drawing cannot be reproduced, copied, retained or used, in whole or in part, without written consent of CB&I LLC, a McDermott company.

Form Number: CMS-875-02-FM-30006 Issued for Use: 21/DEC/2017

PLANT NORTH

KEY PLAN

REGISTERED ARCHITECT
PETER J. STEIN
BRITISH COLUMBIA
2025-04-16

S2ARCHITECTURE
CALGARY | EDMONTON | VANCOUVER

B	ISSUED FOR BUILDING PERMIT	DE	PS	GW	2025MAR18
A	ISSUED FOR 60% FORMAL REVIEW	DE	PS	GW	2025MAR10
NO.	REVISION	DRWN	CK'D	APPD	DATE

MCDERMOTT

THIS DOCUMENT OR DRAWING IS THE SOLE PROPERTY AND COPYRIGHT OF CB&I LLC, A MCDERMOTT COMPANY, AND CONTAINS CONFIDENTIAL AND PROPRIETARY INFORMATION. THIS DOCUMENT OR DRAWING CANNOT BE REPRODUCED, COPIED, RETAINED OR USED, IN WHOLE OR IN PART, WITHOUT WRITTEN CONSENT OF CB&I LLC.

Drawn By	Drwn Date	Chkd By	Chkd Date	Aprvd By	Aprvd Date	Scale
DE	2025MAR18	PS	2025MAR18	GW	2025MAR18	AS NOTED


Woodfibre LNG Project

CLIENT DWG NO:

INDUSTRIAL AREA
01-BLG-0011-INSTRUMENT AIR COMPRESSOR BUILDING
EMERGENCY ACCESS SITE PLAN
ARCHITECTURAL

FOR:
Woodfibre LNG Limited

PROJ. NO: 350106	DWG NO: 350106-SC-CV-001-SD-110178	REV: B
---------------------	---------------------------------------	-----------

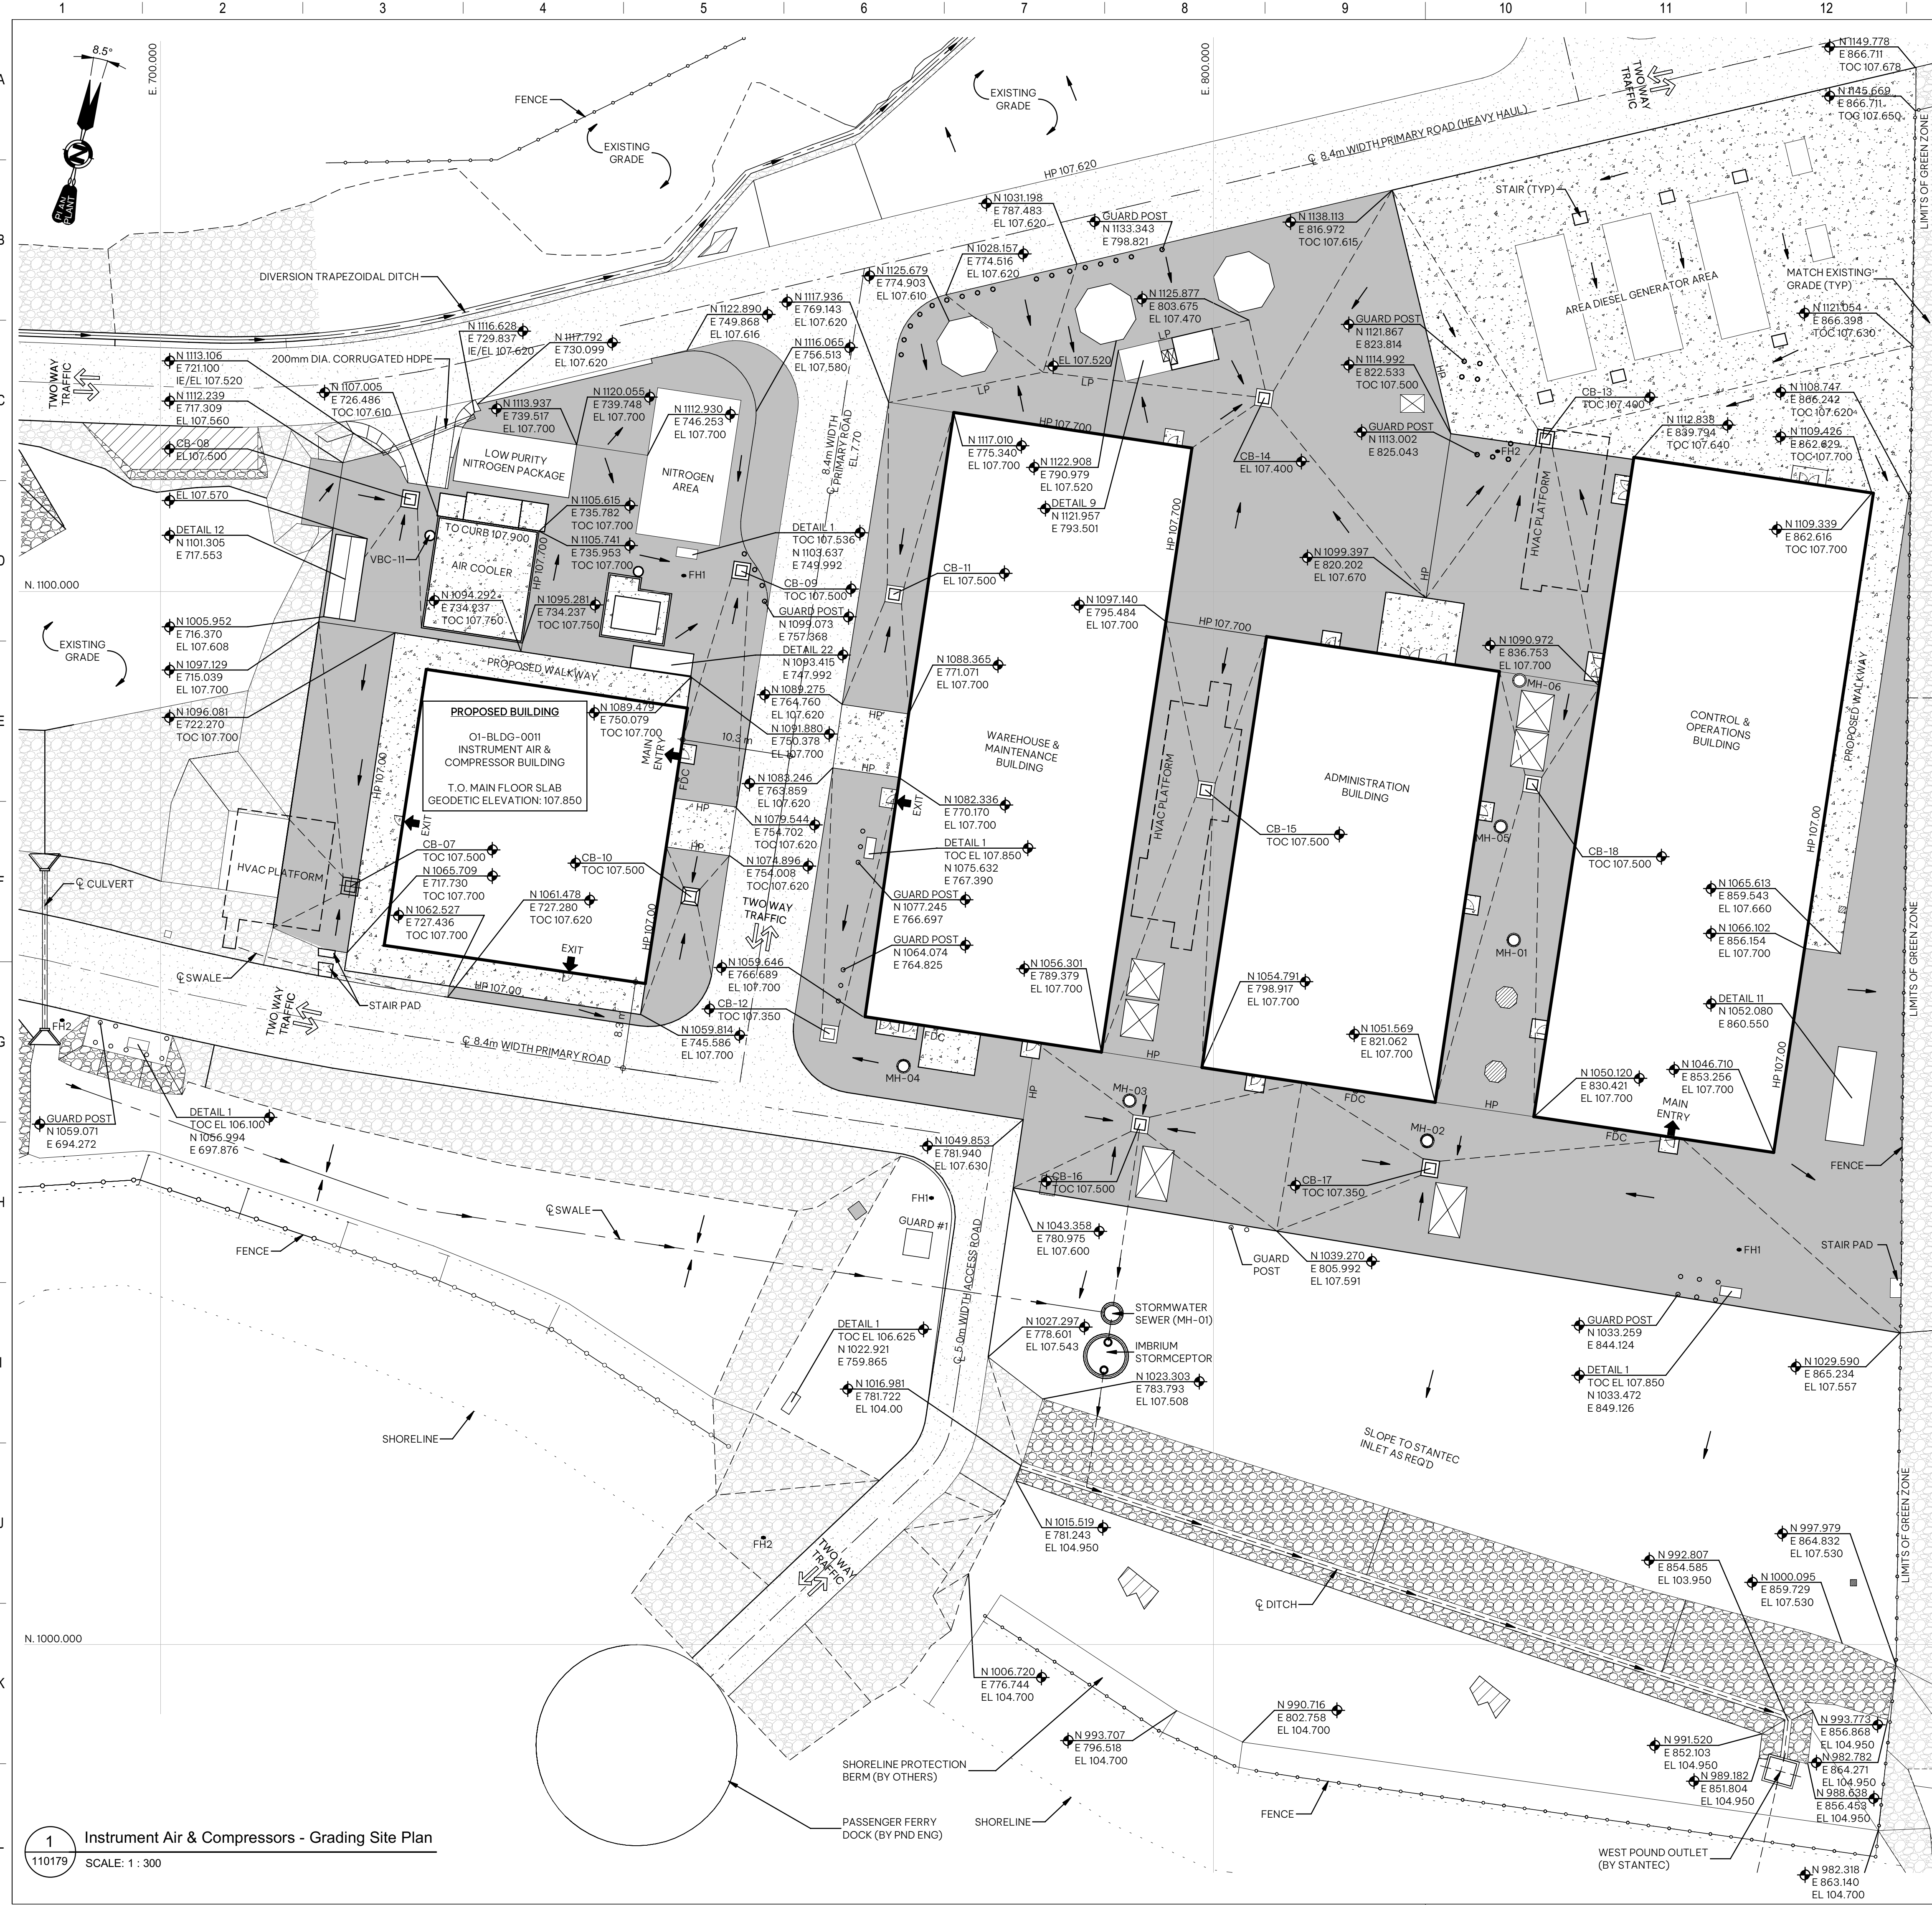


Site - General Notes

- THIS DRAWING SHALL BE READ IN CONJUNCTION WITH CIVIL, LANDSCAPE, MECHANICAL AND ELECTRICAL DRAWINGS AND SPECIFICATIONS. ALL WORK TO BE COORDINATED AND VERIFIED PRIOR TO CONSTRUCTION.
- THE CONTRACTOR IS TO VERIFY ALL SITE DIMENSIONS AND SPOT ELEVATIONS PRIOR TO CONSTRUCTION AND REPORT ANY DISCREPANCIES TO THE ARCHITECT.
- ELEVATIONS IN GEODETIC

Site - Symbol Legend

- INDICATES EXTENT AND LOCATION OF ASPHALT. REFER TO CIVIL DRAWINGS
- INDICATES EXTENT AND LOCATION OF GRAVEL. REFER TO CIVIL DRAWINGS.
- INDICATES EXTENT AND LOCATION OF CONCRETE PAVING. REFER TO CIVIL DRAWINGS.
- INDICATES EXTENT AND LOCATION OF RIPRAP. REFER TO CIVIL DRAWINGS.
- INDICATES EXTENT AND LOCATION OF EXISTING ASPHALT. (COMPLETED RG-PCKG A)
- INDICATES EXTENT AND LOCATION OF EXISTING RIPRAP. (COMPLETED RG-PCKG A)
- ELECTRICAL, MECHANICAL, TELECOM SCOPE
- INDICATES CATCH BASIN. REFER TO CIVIL DRAWINGS
- INDICATES MANHOLE. REFER TO CIVIL DRAWINGS
- INDICATES FIRE HYDRANT. REFER TO CIVIL DRAWINGS
- INDICATES REMOTE ACTUATED FIRE HYDRANT. REFER TO CIVIL DRAWINGS
- FIRE DEPARTMENT CONNECTION. REFER TO MECHANICAL DRAWINGS
- INDICATES PROPOSED GEODETIC SPOT ELEVATION
- INDICATES SECURITY FENCE. REFER TO CIVIL DRAWINGS
- INDICATES PEDESTAL. REFER TO CIVIL DRAWINGS

Building Height Elevation

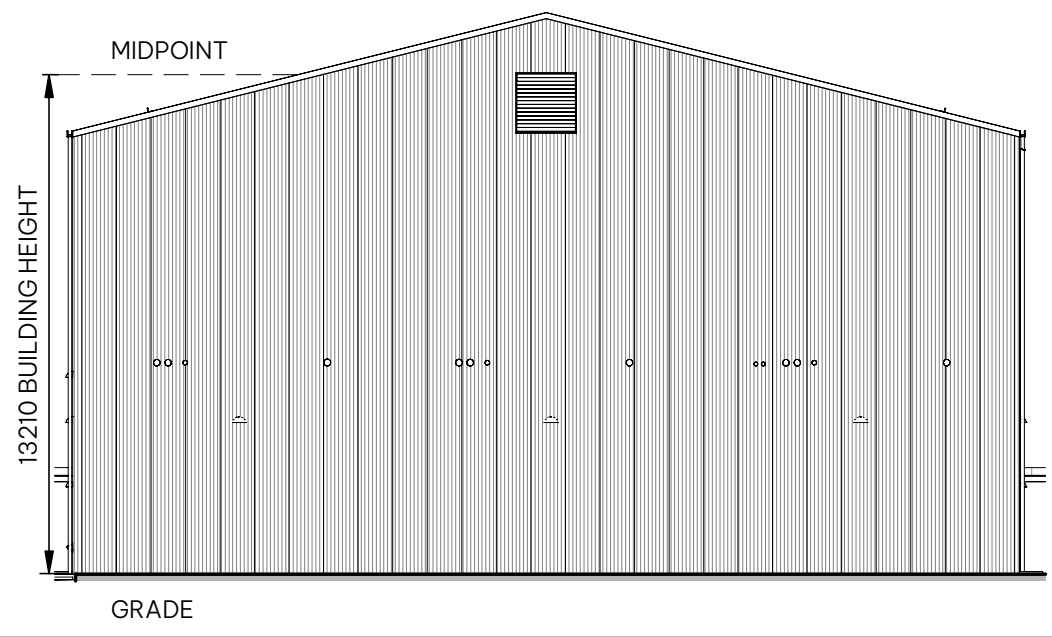

GENERAL NOTES:

- ALL DIMENSIONS ARE IN MILLIMETER, UNO.
- ALL DRAWING REFERENCE CALLOUTS ARE PREFIXED WITH 350106-SC-CV-001-SD, TYPICAL.


SHEET REFERENCES:

350106-SC-CV-001-SD-110001 - COVER SHEET
350106-SC-CV-001-SD-110178 - EMERGENCY ACCESS SITE PLAN

HOLDS:

	SUPPLIER/SUBCONTRACTOR DRAWING DECAL					 Woodfibre LNG																
	WOODFIBRE LNG																					
Supplier Name: LBLNG																						
SDR Code(s): E05																						
Equipment/Tag Number(s):																						
<table><tr><td>Project Number</td><td></td><td>Purchase Order Number</td><td></td><td></td><td></td><td>Seq. No</td></tr><tr><td>350106</td><td>-</td><td>SC-CV-001</td><td>-</td><td>SD</td><td>-</td><td>110179</td></tr></table>						Project Number		Purchase Order Number				Seq. No	350106	-	SC-CV-001	-	SD	-	110179	<table><tr><td>Purchaser's Revision</td></tr><tr><td>2</td></tr></table>	Purchaser's Revision	2
Project Number		Purchase Order Number				Seq. No																
350106	-	SC-CV-001	-	SD	-	110179																
Purchaser's Revision																						
2																						

This document or drawing is the sole property and copyright of CB&I LLC and contains confidential and proprietary information. This document or drawing cannot be reproduced, copied, retained or used, in whole or in part, without written consent of CB&I LLC, a McDermott company.

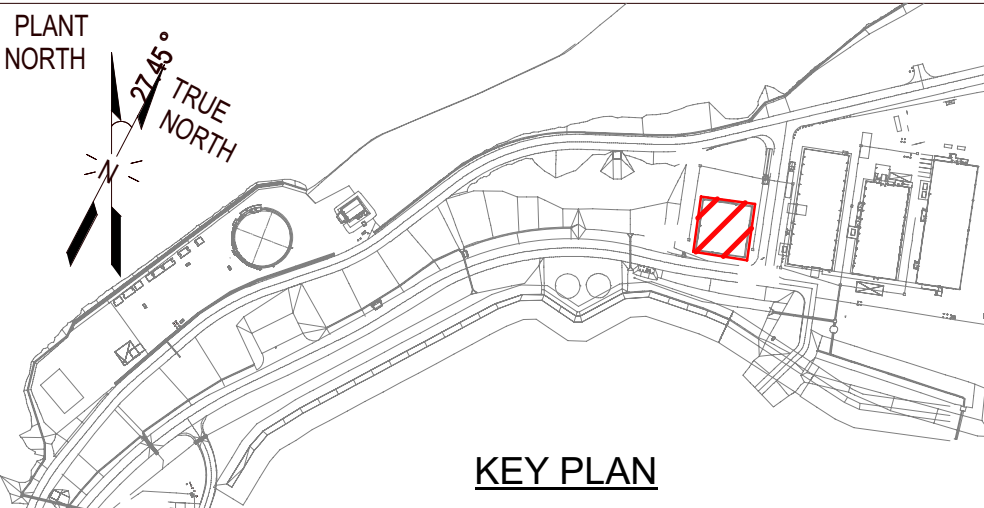

REFERENCE ONLY

S2ARCHITECTURE
CALGARY | EDMONTON | VANCOUVER

B	ISSUED FOR BUILDING PERMIT	DE	PS	GW	2025MAR18
A	ISSUED FOR 60% FORMAL REVIEW	DE	PS	GW	2025MAR10
NO.	REVISION	DRWN	CK'D	APPD	DATE

MCDERMOTT

THIS DOCUMENT OR DRAWING IS THE SOLE PROPERTY AND COPYRIGHT OF CB&I LLC, A MCDERMOTT COMPANY, AND CONTAINS CONFIDENTIAL AND PROPRIETARY INFORMATION. THIS DOCUMENT OR DRAWING CANNOT BE REPRODUCED, COPIED, RETAINED OR USED, IN WHOLE OR IN PART, WITHOUT WRITTEN CONSENT OF CB&I LLC.

Drawn By	Drwn Date	Chkd By	Chkd Date	Aprvd By	Aprvd Date	Scale
DE	2025MAR18	PS	2025MAR18	GW	2025MAR18	AS NOTED

Woodfibre LNG Project

CLIENT DWG NO:

INDUSTRIAL AREA
01-BLG-0011-INSTRUMENT AIR COMPRESSOR BUILDING
GRADING SITE PLAN
ARCHITECTURAL

FOR: Woodfibre LNG Limited		REV:	
PROJ. NO:	DWG NO:		
350106	350106-SC-CV-001-SD-110179		